

Approved for Construction, with all Terms
and Conditions mentioned in Order No.
Case No. 10/MRC-81/17 (Special Township)
(2009-2010, Dated 27/1/2014)

For Collector, Nagpur.



FIRE CONSULTANT

ALERT MULTIPURPOSE SERVICES

202, Agrawal Marg,
Rani Durgavati Square,
Nagpur-440017
Contact No: 937225184
Office: 0713-3201027
email: am.s.fire.consultant@gmail.com

INDEX

- FIRE DOOR
- ABC FIRE EXTINGUISHERS
- FIRE PUMP
- FIRE CONTROL PANEL
- FIRE MANUAL CALL POINT
- FIRE HOOTER
- FIRE HYDRANT VALVE
- HP = HYDRANT PIPE
- HR = HOSE REEL
- HB = HOSE BOX
- FIRE SERVICE INLET
- BUTTERFLY VALVE
- NON RETURN VALVE
- YARD HYDRANT STAND POST
- 0.100M DIA PIPE LINE

REVISED BUILDING PLAN FOR DAFFODIL HIGH TYPE - E 2-3 BHK INCLUDING FIRE HYDRANT PLAN

SCHEDULE OF DOOR/WINDOW

NO	OPENING SIZES	SILL/SOFT LVL	LINTEL LVL	LOCATION
D1	1.65 X 2.10	0.00	2.10	ENTRY TO FLAT
D2	0.90 X 2.10	0.00	2.10	BED ROOM - 1, 2 & BAL - 2
D3	0.75 X 2.10	0.00	2.10	TOILET - 1, 2
SD1	2.40 X 2.1	0.00/3.1	3.1	BALCONY-1
W1	1.25 X 1.20	0.900/2.10	2.10	BED ROOM
W2	1.350 X 1.20	0.900/2.10	2.10	BED ROOM
W3	1.920 X 1.20	0.900/2.10	2.10	BED ROOM
W4	0.900 X 1.20	0.900/2.10	2.10	DINING
W5	0.650 X 1.20	0.900/2.10	2.10	DINING
W6	2.840 X 1.5	0.90/2.10	2.40	LEFT LOBBY WINDOW
W7	0.900 X 1.20	0.900/2.10	2.10	KITCHEN
W8	0.600 X 0.90	1.20/2.10	2.10	TOILET - 1, 2

MOUZA - KOTHEWADA
TAL. - HINGNA
GROUP HOUSING PLOT R-2.7

PREVIOUS DEVELOPMENT
PERMISSION NO.
01/MRC-81/(M.R.T.P./SPECIAL
TOWNSHIP)/2009-2010, DATED
27/01/2014

OWNERS SIGNATURE

FOR FIRE ARCOR INFRASTRUCTURE PVT LTD
MANAGING DIRECTOR

Choudhary Consultants
Architects, Engineers & Project Management Consultants
B-10/10A, COTTA ROAD LAYOUT, BIRAJANG TOWNSHIP,
NAGPUR-440015 (M.S.) INDIA. PH: 0713-2580350
EMAIL: choudharyconsultants@gmail.com

SIGNATURE OF ARCHITECT


CLIENTS : FIRE ARCOR INFRASTRUCTURE
PVT.LTD.,

PROJECT : RESIDENTIAL
DEVELOPMENT FOR
FIRE ARCOR INFRASTRUCTURE
PVT.LTD., NAGPUR


DRAWING TITLE :
GROUND & TYPICAL
FLOOR PLAN (18 - X)
(3/2 BHK STD. MID RISE) (BLOCK B)

DATE-30-08-16
DRAWN BY--PRAVIN
CHECKED--Ar. DILIP, P.
FILE: AZAZ/E/DWG/NAGPUR/ (3/2 BHK STD. HIGH RISE)

SCALE : 1:100
DRAWING NO./REV. NO.
A/E- 01

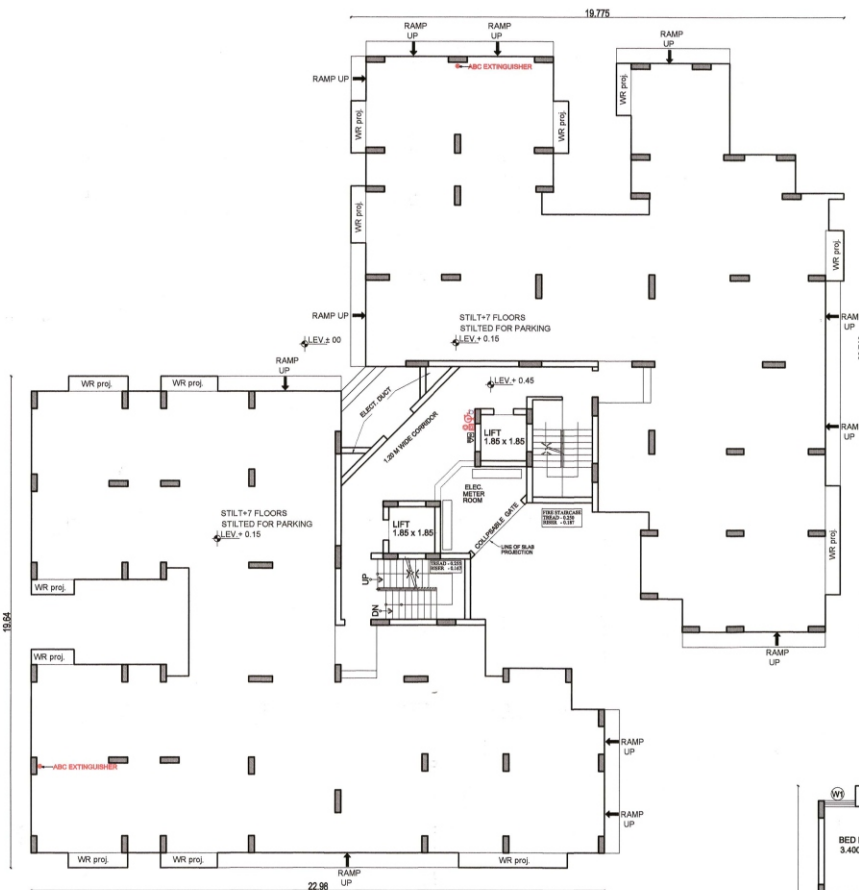

GROUND FLOOR PLAN

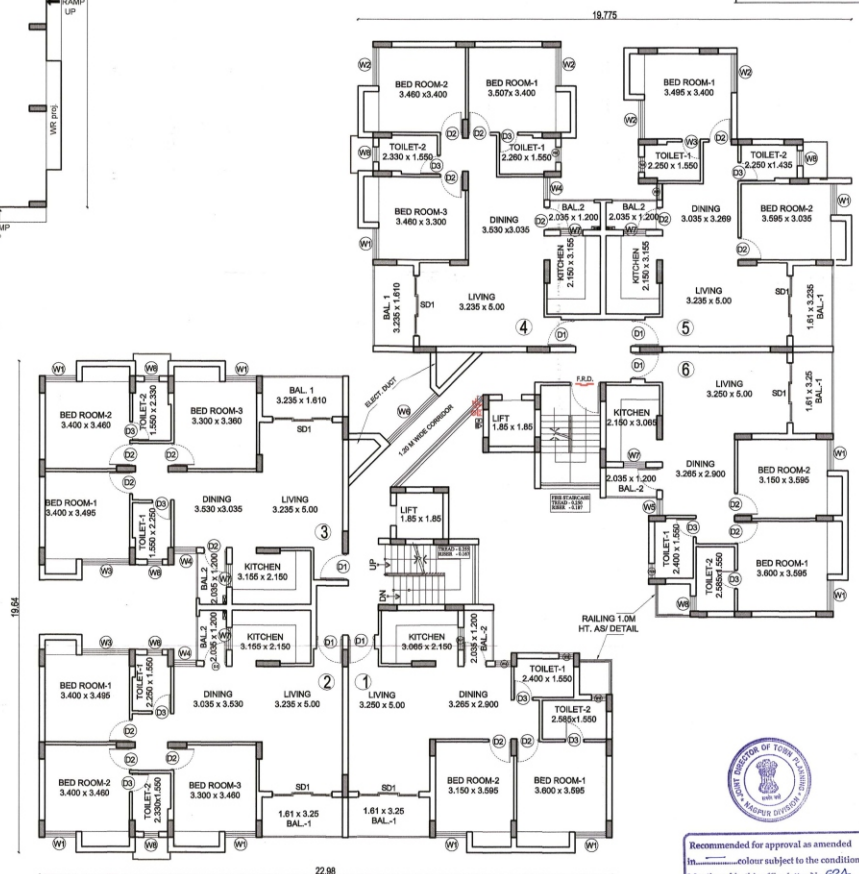

TYPICAL FLOOR PLAN
(1ST TO 7TH FLOOR PLAN)



Recommended for approval as amended
in _____ colour subject to the conditions
Mentioned in this office letter No. 62A-
Dtd. 6/5/17

Joint Director of Town Planning
Nagpur Division, Nagpur