



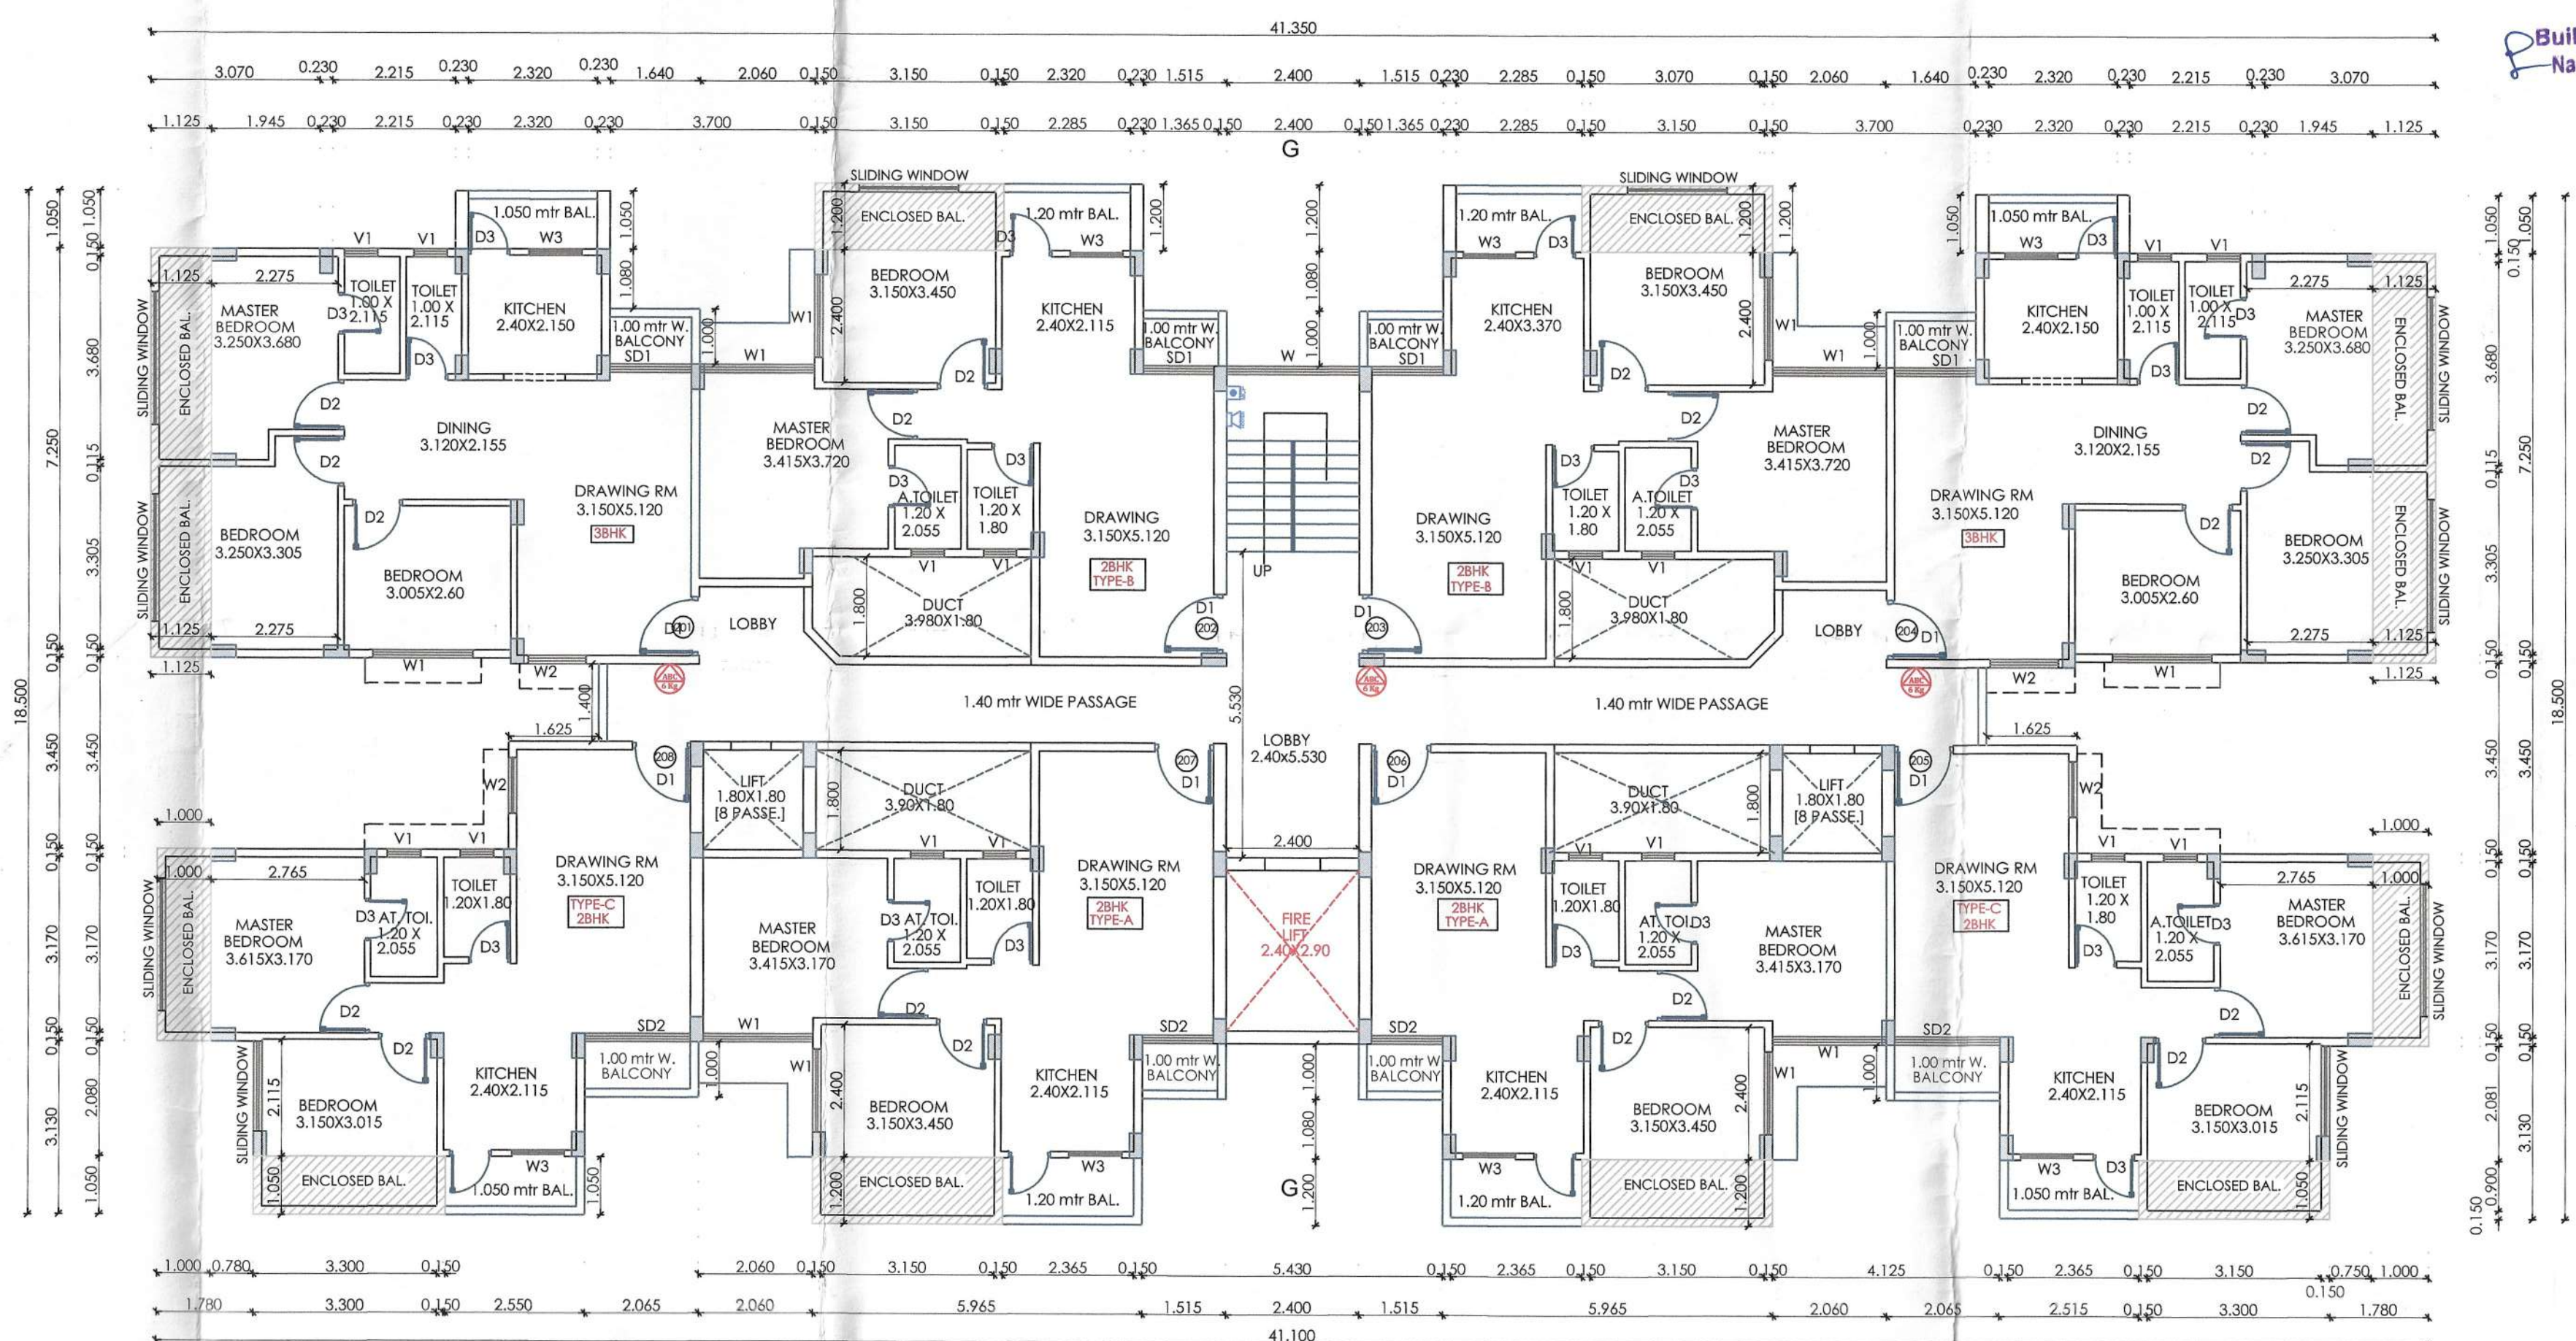


WING C
SECOND FLOOR PLAN
SCALE:- 1 : 100

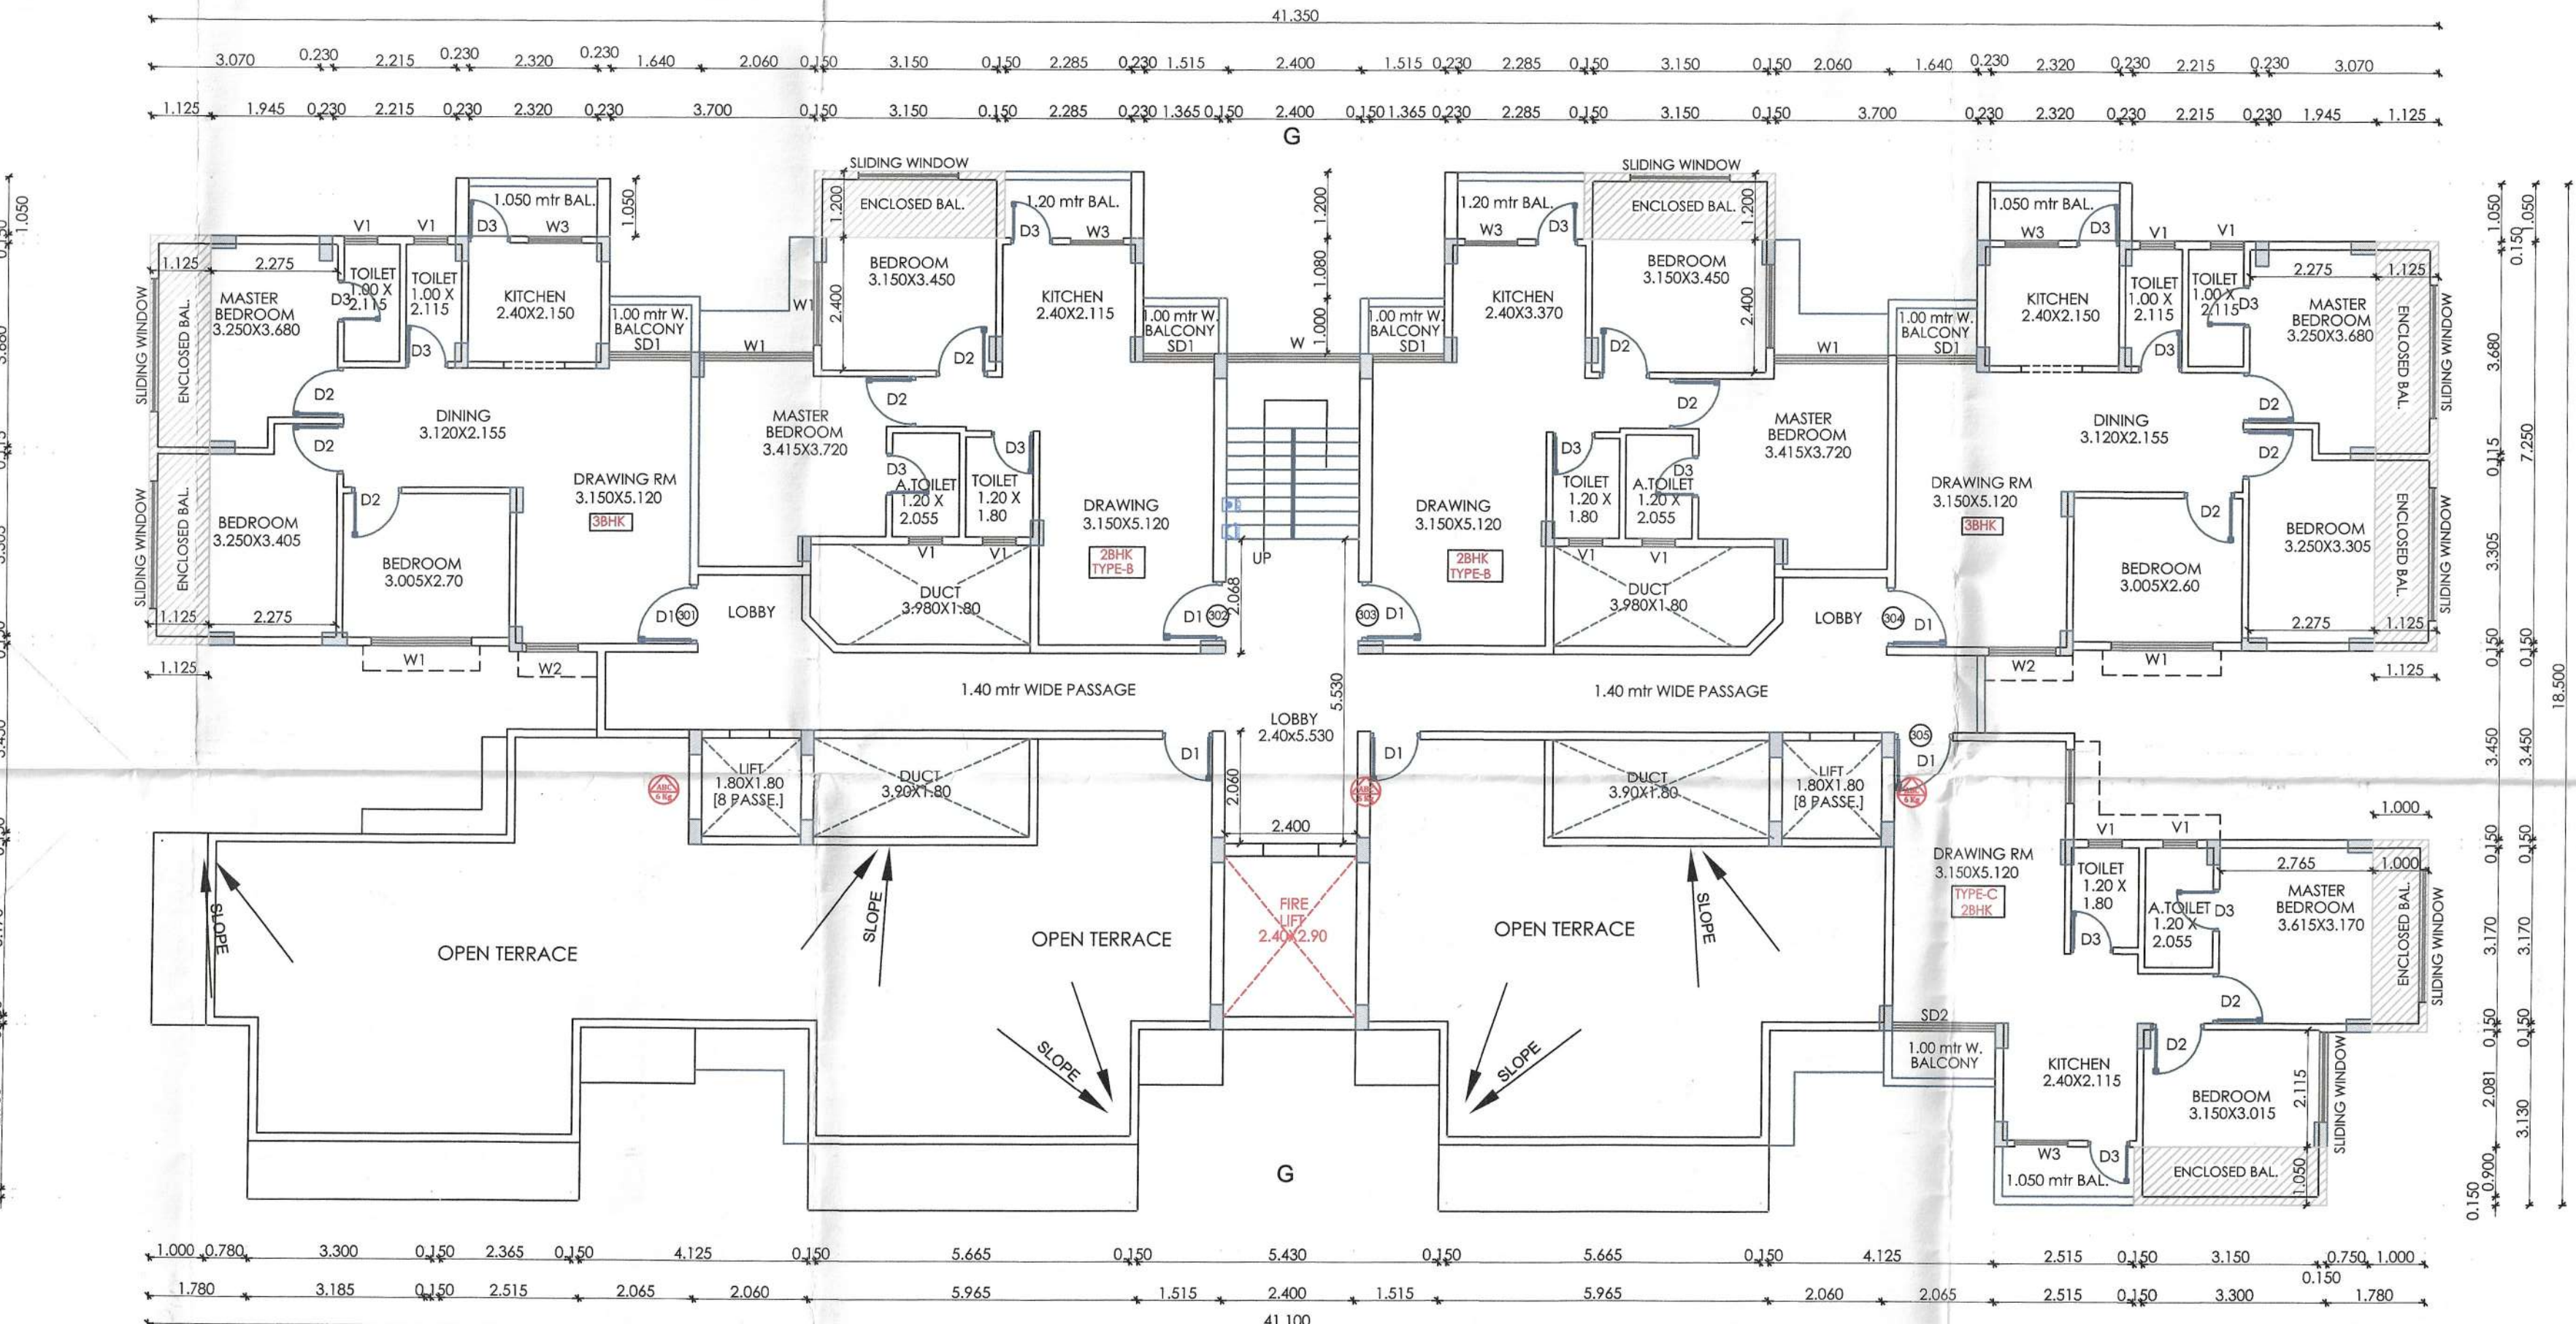


WING C
THIRD FLOOR PLAN
SCALE:- 1 : 100

Tentatively Approved
For Fire N.O.C. Only
Building Engineer(North)
Nagpur Improvement Trust

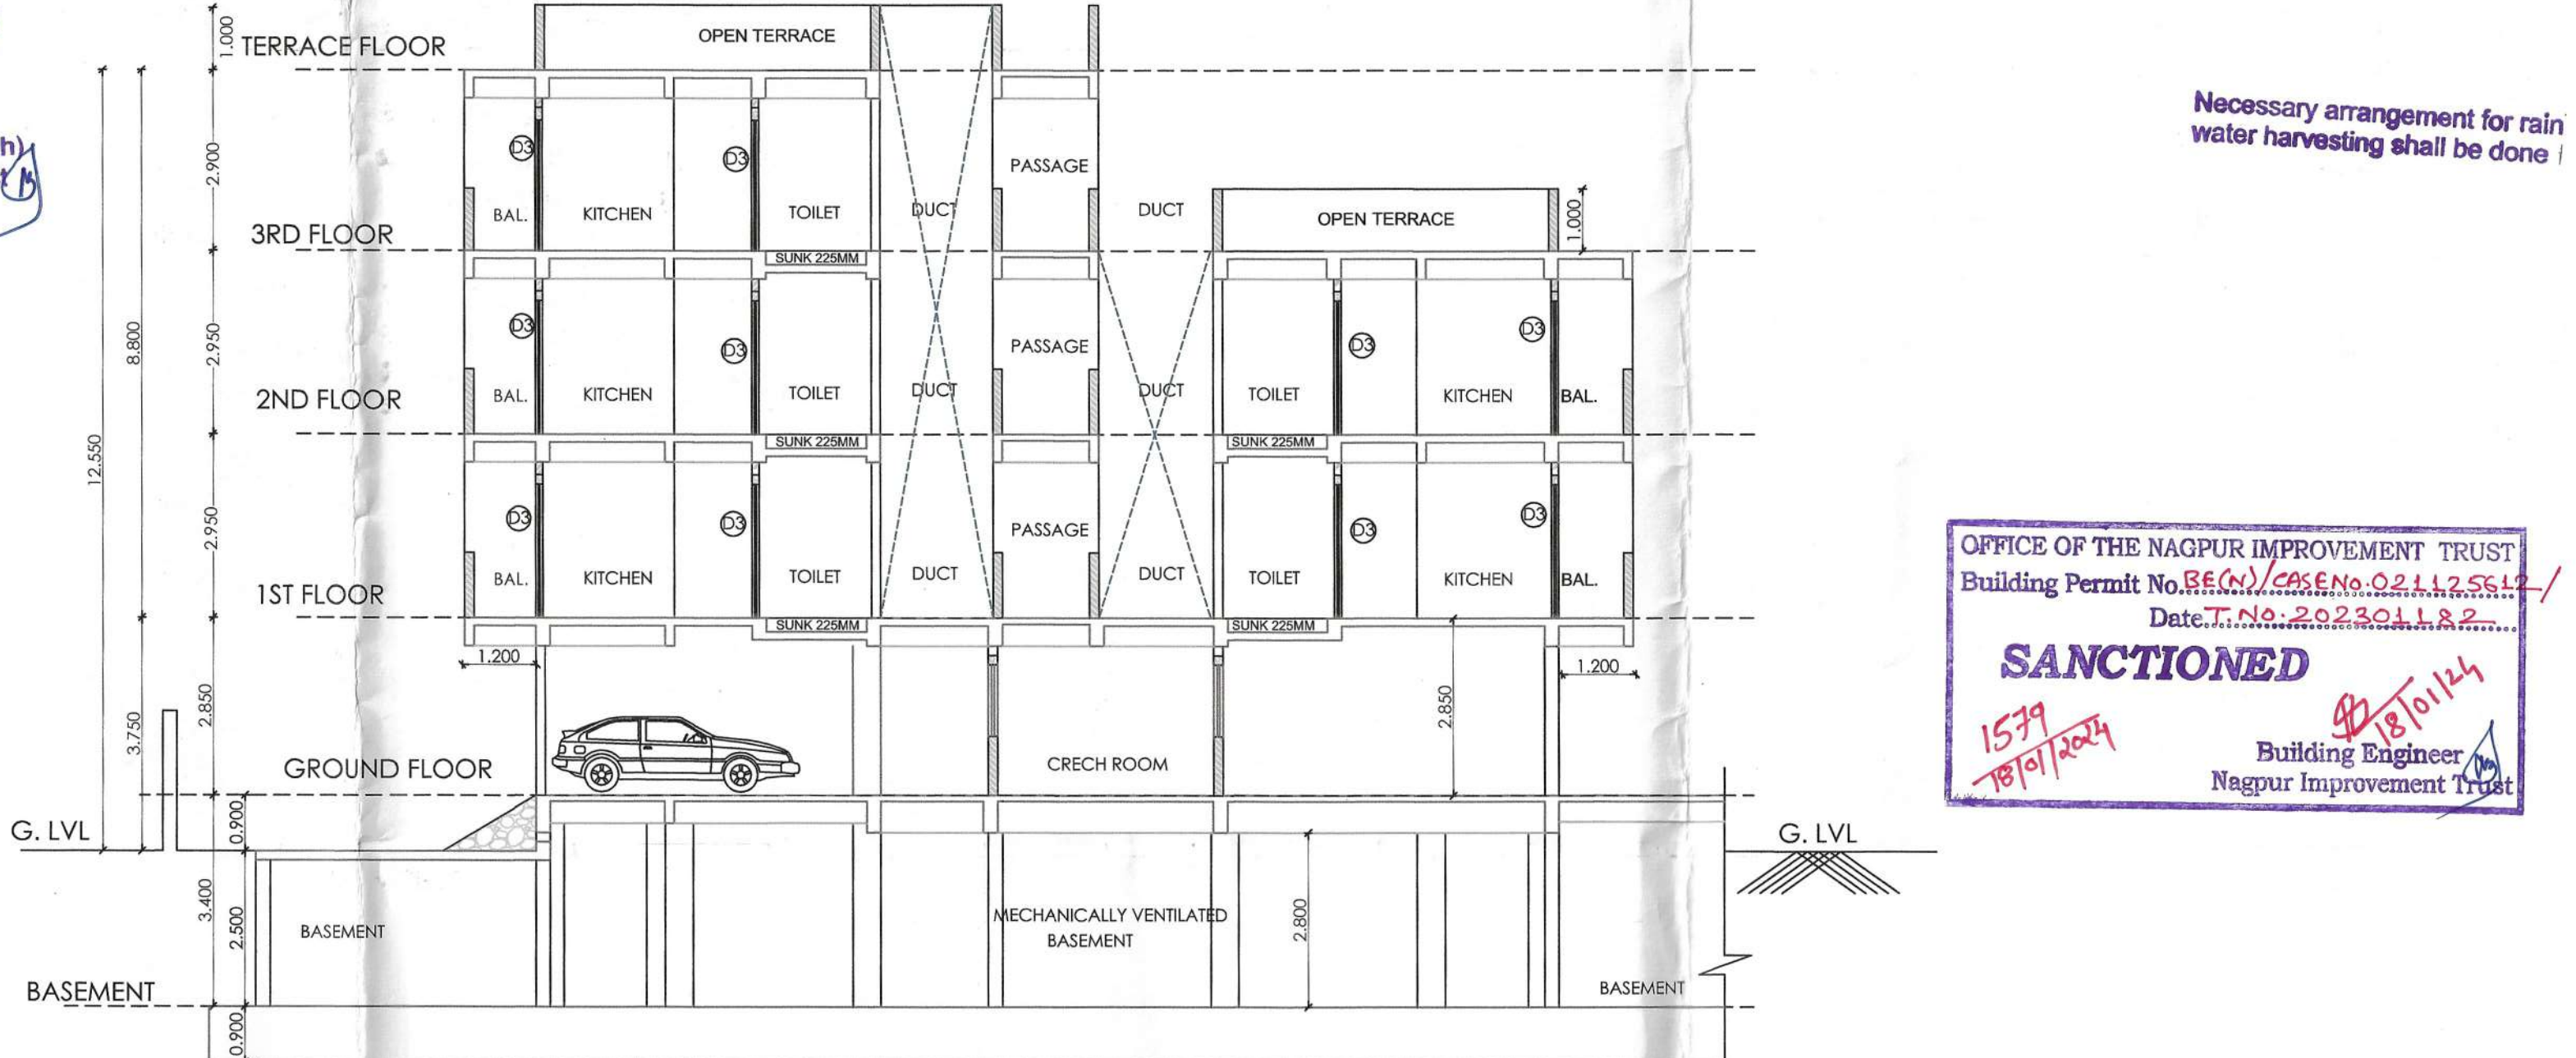

SECTION 'H-H' SCALE:- 1:100

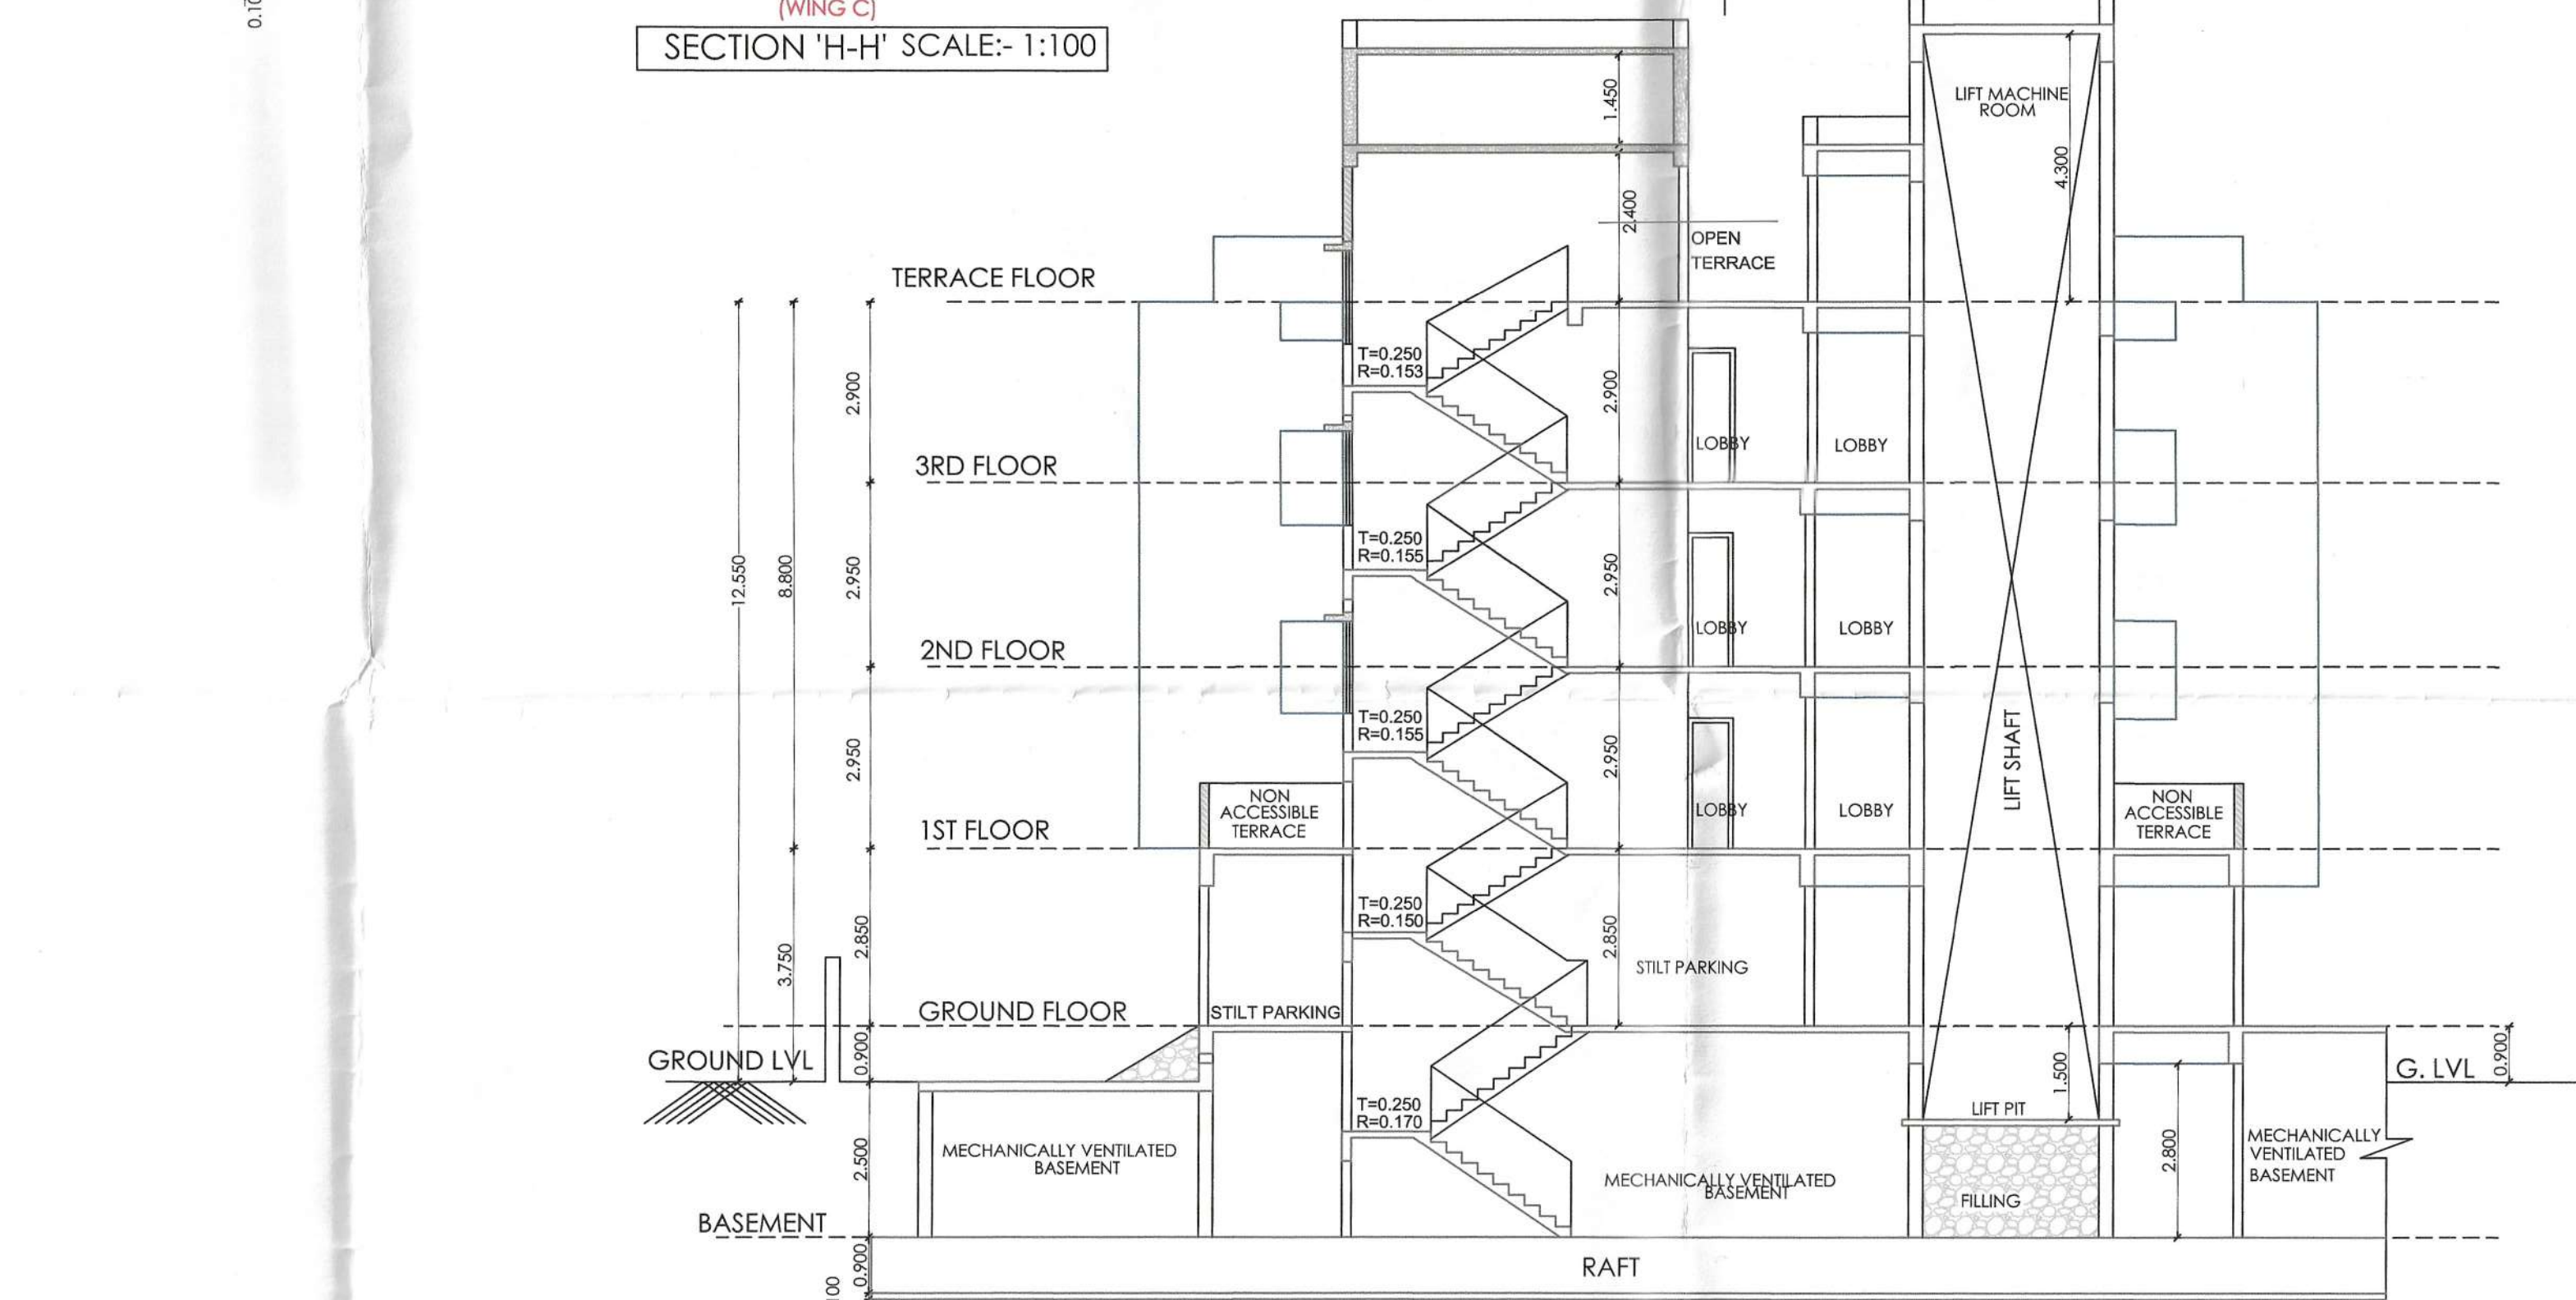

SECTION 'G-G' SCALE:- 1:100



R.H.S. (EAST) ELEVATION SCALE:- 1:100

Necessary arrangement for rain
water harvesting shall be done

OFFICE OF THE NAGPUR IMPROVEMENT TRUST
Building Permit No. 1579/2023
Date: 15/12/2023
SANCTIONED
Building Engineer
Nagpur Improvement Trust

FIRE AND EMERGENCY SERVICE
APPROVED
VIDE LETTER NO. CF-01/2023
(The Scope of this approval is restricted to
fire protection arrangements only, this approval
should not be treated as approval
for Civil/Architectural drawings)
Chief Fire Officer
N.M.R.D.A./N.I.T., Nagpur

This plan is approved for
Fire Safety Point of view only,
signed in token of Approved Subject
to requirement also.
CF-01/FES/NMRDA/113/2210812023

SHEET : 9/9 - WING - C

PROPOSED BUILDING PLAN FOR MULTI FAMILY DWELLING
UNIT ON K.H. NO 248/2, C.T.S. NO. 1042, SHEETNO. 550/83,
WARD NO. 61, MOUZA -ZINGABAI TAKLI (CITY)
TEHSIL & DIST. NAGPUR

BELONGS TO:-
1) MR. MAHESH S/O CHANDRABHAN KINGRANI
2) MR. RAJESH S/O CHANDRABHAN KINGRANI

L.S. No. 1820
Serial No. 1579/2023
Valid upto: 31/12/2026

OFFICE OF THE NAGPUR IMPROVEMENT TRUST
Building Permit No. 1579/2023
Date: 15/12/2023
SANCTIONED
Building Engineer
Nagpur Improvement Trust

D1	DOOR	1.065 x 2.150	T.W. PANEELED DOOR
D2	DOOR	1.000 x 2.150	DO
D3	DOOR	0.750 x 2.150	DO
SD1	SLIDING WINDOW	1.800 x 1.250	DO
SD2	SLIDING WINDOW	1.400 x 1.250	DO
FRD	FIRE DOOR	1.050 x 2.150	DO
W	WINDOW	2.400 x 1.200	DO
W1	WINDOW	1.800 x 1.500	DO
W2	WINDOW	1.000 x 1.500	DO
W3	WINDOW	0.950 x 1.250	DO
V	VENTILATOR	0.600 x 0.600	DO

TERRACE TANK DETAILS - TERRACE TANK FOR FIRE FIGHTING CAPACITY 02 NO. X 10 KL (3.17 X 2.56 X 1.23 M H)			
UG TANK DETAILS - UNDERGROUND WATER TANK FOR FIRE FIGHTING CAPACITY 50 KL (6.00 X 4.00 X 2.08 M DEEP)			
PUMP DETAILS - 1) MAIN PUMP 1620 LPM - 01 NO. 2) DIESEL PUMP 1620 LPM - 01 NO. 3) JOCKEY PUMP 180 LPM - 01 NO. 4) BOOSTER PUMP 450 LPM - 02 NO.			

SCHEDULE OF OPENING			
D1	DOOR	1.065 x 2.150	T.W. PANEELED DOOR
D2	DOOR	1.000 x 2.150	DO
D3	DOOR	0.750 x 2.150	DO
SD1	SLIDING WINDOW	1.800 x 1.250	DO
SD2	SLIDING WINDOW	1.400 x 1.250	DO
FRD	FIRE DOOR	1.050 x 2.150	DO
W	WINDOW	2.400 x 1.200	DO
W1	WINDOW	1.800 x 1.500	DO
W2	WINDOW	1.000 x 1.500	DO
W3	WINDOW	0.950 x 1.250	DO
V	VENTILATOR	0.600 x 0.600	DO

PLOT BOUNDARY SHOWN IN PROPOSED CONSTRUCTION SHOWN IN			
NOTE :- ALL DIMENSIONS ARE IN METERS			
Owners Name & Signature :-	M/S IKON REMEDIES PVT. LTD.	Represented Through:-	1)MR. MAHESH S/O CHANDRABHAN KINGRANI 2)MR. RAJESH S/O CHANDRABHAN KINGRANI
Architect Name & Signature :-	SYED MOBIN ARCHITECTS	Regn. No.-CA/2002/29182 NIT Survey No. 1820 NMC Lic. No.- NMC/R-263	
ARCHITECT SYED MOBIN ARCHITECTS PLANNING, ARCHITECTURAL & INTERIOR CONSULTANTS 301.7/2, STYLE HOMES, BYRAMJI TOWN, NAGPUR (M.S.) - 440013. PHONE: (0712) 2588900, 2588901 WEBSITE: www.syedmobin.com, EMAIL: sma@indiaivision.com			

LEGENDS -

ABC FIRE EXTINGUISHER	ABC FIRE EXTINGUISHER
CO2 FIRE EXTINGUISHER	CO2 FIRE EXTINGUISHER
FIRE PUMP	FIRE PUMP
FIRE SPRINKLE - PENDENT TYPE - 68 DC	FIRE SPRINKLE - PENDENT TYPE - 68 DC
FIRE ALARM CONTROL PANEL	FIRE ALARM CONTROL PANEL
FIRE MANUAL CALL POINT	FIRE MANUAL CALL POINT
FIRE HOOTER WITH PA TALK BACK	FIRE HOOTER WITH PA TALK BACK
FIRE HYDRANT VALVE	FIRE HYDRANT VALVE
HR-HOSE REEL	HR-HOSE REEL
HB-HOSE BOX	HB-HOSE BOX
AIR RELEASE VALVE	AIR RELEASE VALVE
BUTTERFLY VALVE	BUTTERFLY VALVE
BALL VALVE	BALL VALVE
NRV-NON RETURN VALVE	NRV-NON RETURN VALVE
BELLOW	BELLOW
Y-STRAINER	Y-STRAINER
MV-MECHANICAL VENTILATION (EXHAUST BLOWER/FAN)	MV-MECHANICAL VENTILATION (EXHAUST BLOWER/FAN)
FIRE HYDRANT STAND POST	FIRE HYDRANT STAND POST
FIRE SERVICE INLET	FIRE SERVICE INLET
BUTTERFLY VALVE	BUTTERFLY VALVE
NON RETURN VALVE	NON RETURN VALVE
150 NB PIPE LINE - HYDRANT	150 NB PIPE LINE - HYDRANT
100 NB PIPE LINE - HYDRANT	100 NB PIPE LINE - HYDRANT
100 NB PIPE LINE - SPRINKLER	100 NB PIPE LINE - SPRINKLER
80 NB PIPE LINE	80 NB PIPE LINE
50 NB PIPE LINE	50 NB PIPE LINE
40 NB PIPE LINE	40 NB PIPE LINE
32 NB PIPE LINE	32 NB PIPE LINE
25 NB PIPE LINE	25 NB PIPE LINE

TERRACE TANK DETAILS - TERRACE TANK FOR FIRE FIGHTING CAPACITY 02 NO. X 10 KL (3.17 X 2.56 X 1.23 M H)			
UG TANK DETAILS - UNDERGROUND WATER TANK FOR FIRE FIGHTING CAPACITY 50 KL (6.00 X 4.00 X 2.08 M DEEP)			
PUMP DETAILS - 1) MAIN PUMP 1620 LPM - 01 NO. 2) DIESEL PUMP 1620 LPM - 01 NO. 3) JOCKEY PUMP 180 LPM - 01 NO. 4) BOOSTER PUMP 450 LPM - 02 NO.			

FIRE CONSULTANT & CONTRACTOR - M/S PREFIX ENTERPRISES ADD-PLOT NO. 15, VAISHNA MATA NAGAR, HUDKESHWAR POLICE STATION, PIPLA ROAD, NAGPUR. MOB. NO. 8149977886 Email:- prefix.enterprises@gmail.com LICENCE NO - MFS - LA/RF-545 LICENCE NO - MFS - LA/RD-523 LICENCE NO - MFS - LA/RP-NIL			
FIRE CONSULTANT SEAL & SIGN- PREFIX ENTERPRISES Plot No. 15, Vaishnav Mata Mandir, Pipla Road, Nagpur-440034 LICENCE NO: MFS-LA/RF-545 MFS-LA/RD-523			

AUTHORISED SIGNATORY DESIGN BY - A.V.K DATE - 03/07/2023 SCALE - 1:100	DRAWN BY - A.V.K CHECKED BY - VAIBHAV G. APPROVED BY - VAIBHAV G.	SHEET - FF-REV-0 09 OF 09
--	--	---------------------------------