

Issued by B.P. Cell / Greater Mumbai / Mhada
Read Along with this office letter
No. Mhada - 64/13/8/2022
Date 26 JUL 2023
Ex. Eng. B.P. Cell GM/Mhada (W.S.)

PROFORMA 'B'

CONTENTS OF SHEET :
BASEMENT (PUMP ROOM & TANK) FLOOR PLAN

DESCRIPTION OF PROPOSAL & PROPERTY
PROPOSED DEVELOPMENT ON PLOT C-2,
TOWER-III (WING - L TO - P) NOWN AS MAHARASHTRA POLICE CO-OP.
HSG. FEDERATION LTD., AT DADASAHEB GAIKWAD NAGAR, MALVANI,
MALAD BEARING C.T.S. NO. 3525(P.T) OF VILLAGE MALVANI AT
GOREGAON(W), MUMBAI- 400095.

NAME, ADDRESS OF THE OWNER AND SIGNATURE

For MS MAHARASHTRA POLICE CO-OPERATIVE
HOUSING FEDERATION LTD

Director

MAHARASHTRA POLICE CO-OP. HSG. FEDERATION LTD.

NAME, ADDRESS OF DEVELOPER
MAHARASHTRA POLICE CO-OP. HSG. FEDERATION LTD.
PLOT NO. C2, C.T.S. NO. 3525(P.T) AT DADASAHEB GAIKWAD NAGAR,
MALVANI, MALAD (W), MUMBAI.


REVISION	DATE	SCALE	DRN BY	CHK BY
		1:100	HARISH	

STAMP AND DATE OF APPROVAL OF PLANS


NAME, ADDRESS & SIGNATURE OF ARCHITECT



AR. HEMANT ANKARAIYA
[ARCHITECT] [CA/99/25011]

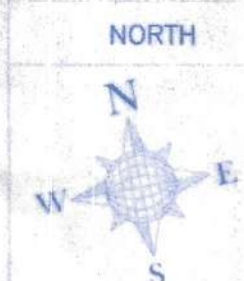

Deeksha
City Scape
D4/68 S.V.P. NAGAR, LOKHANDWALA
COMPLEX, ANDHERI (WEST), MUMBAI - 400 053

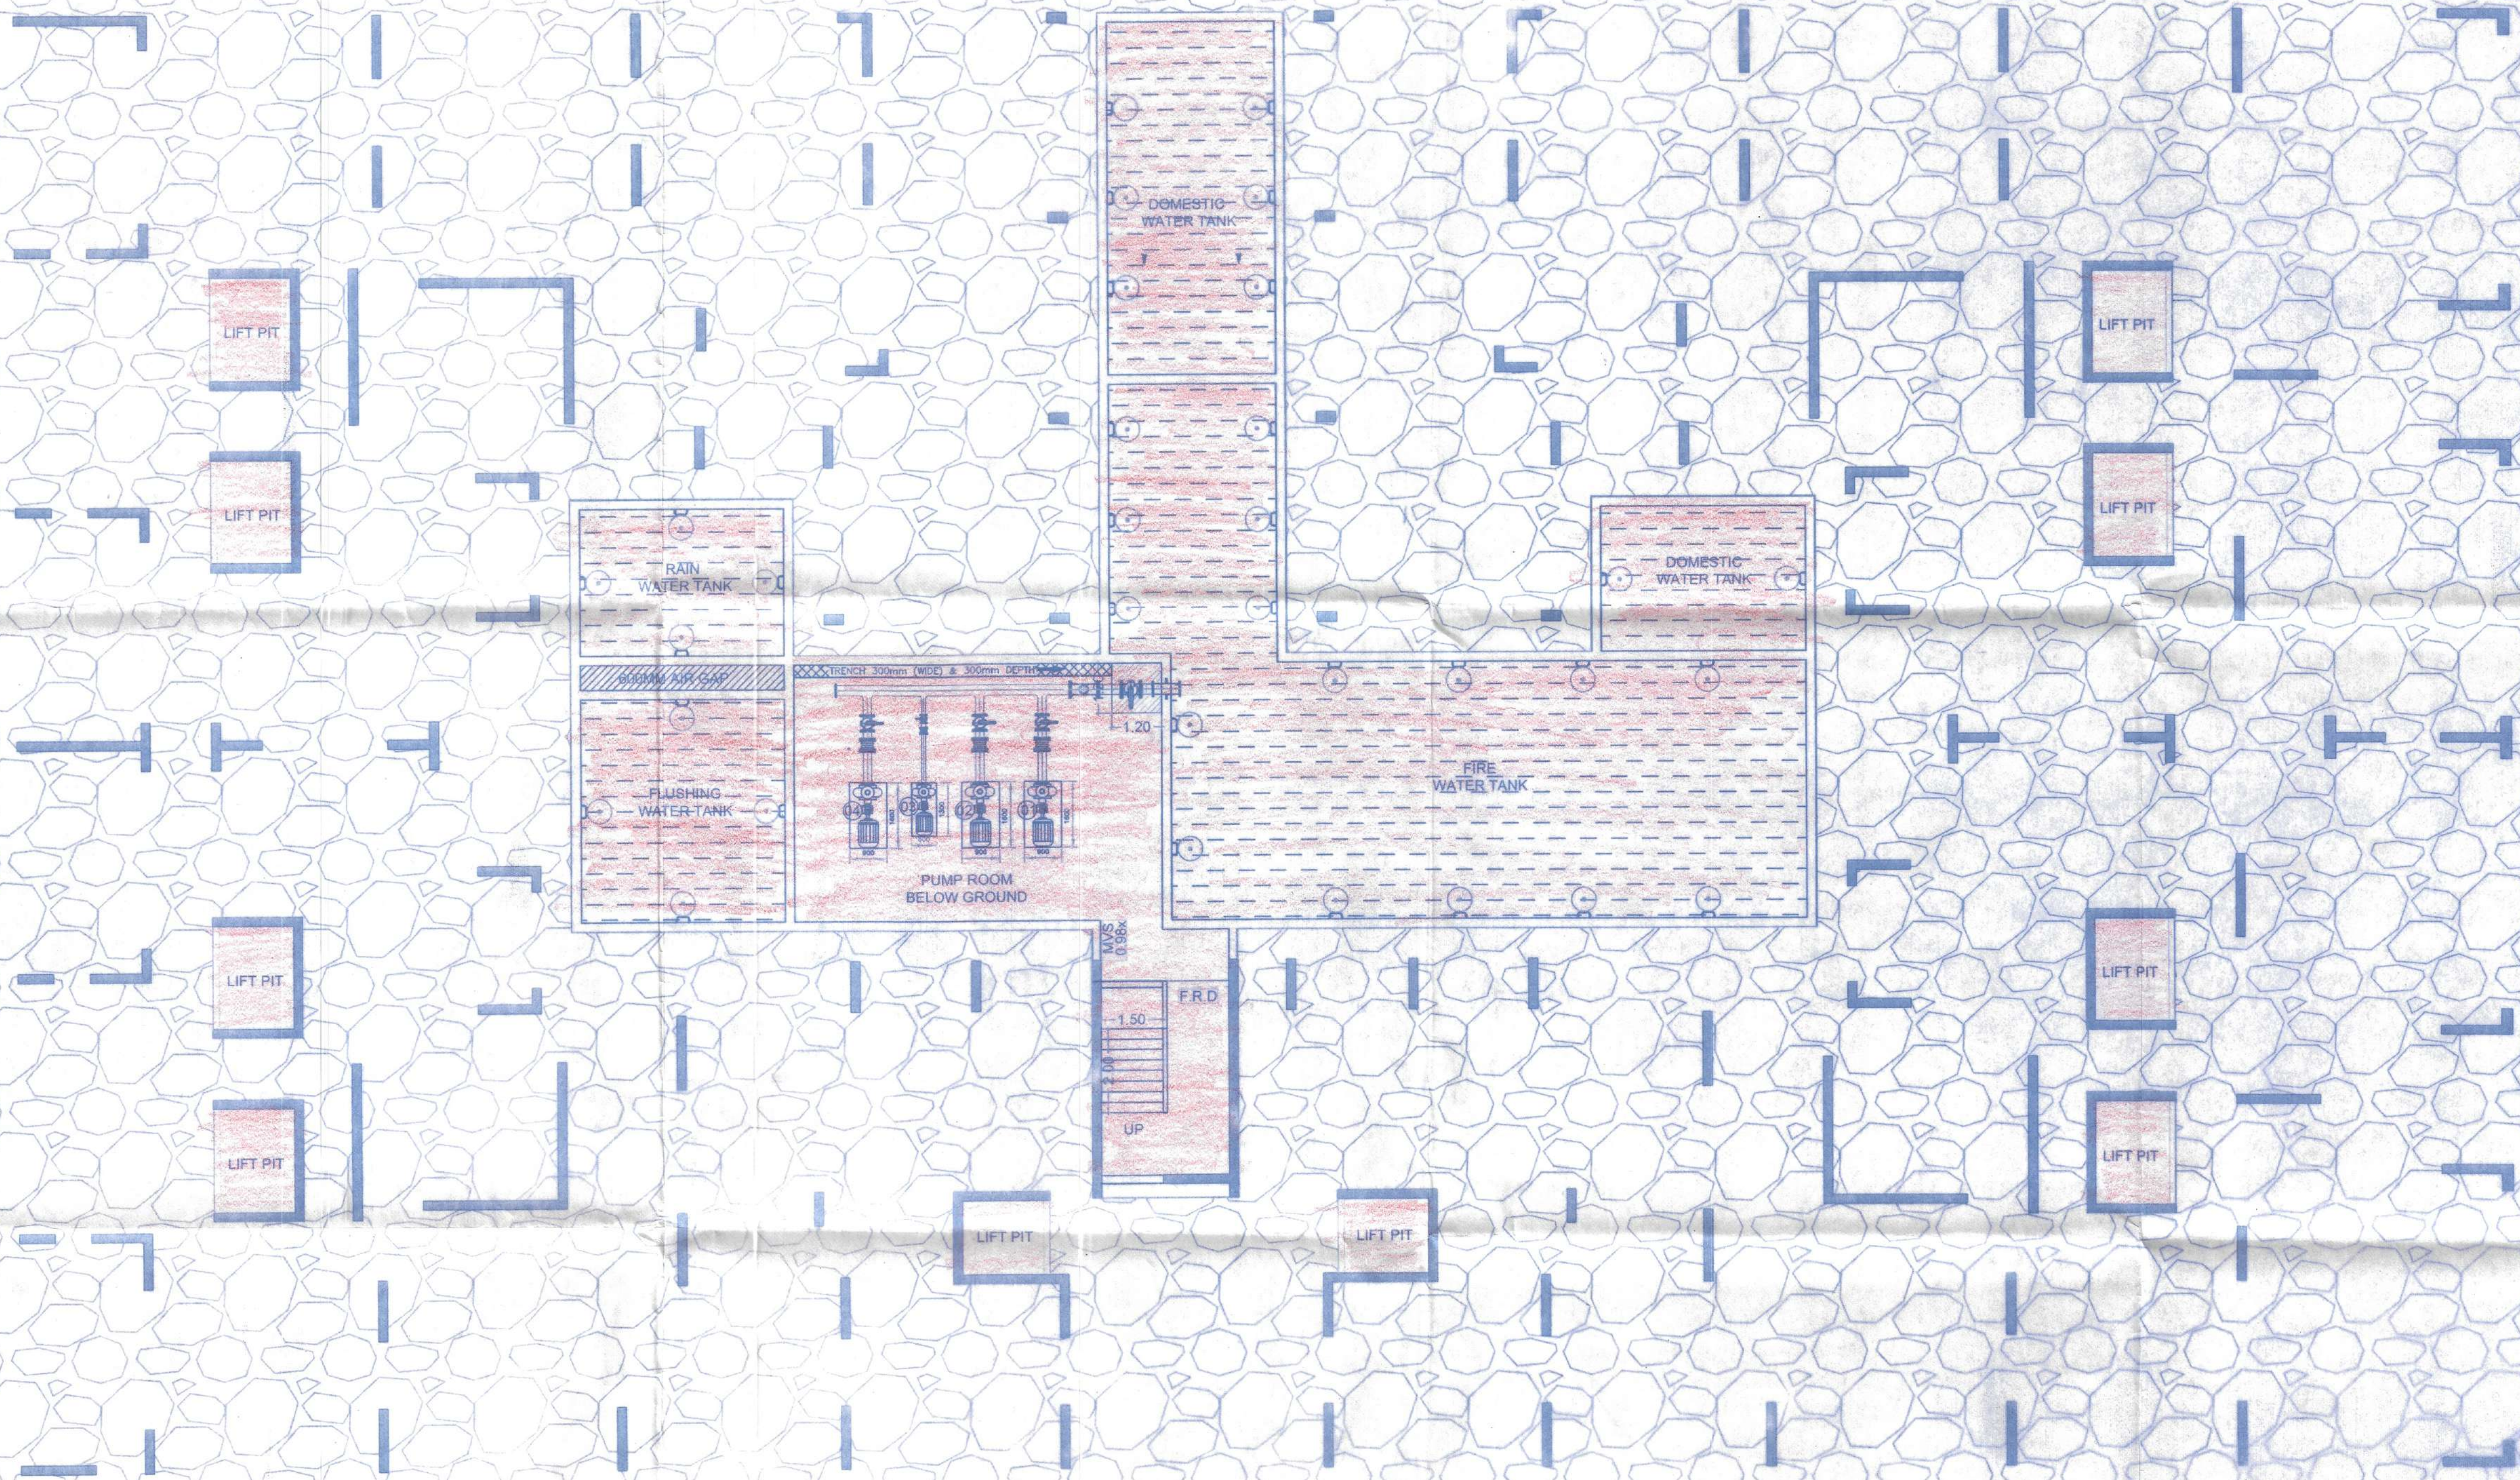

(T-III) BASEMENT (PUMP ROOM & TANK) FLOOR PLAN
SCALE: 1:100