

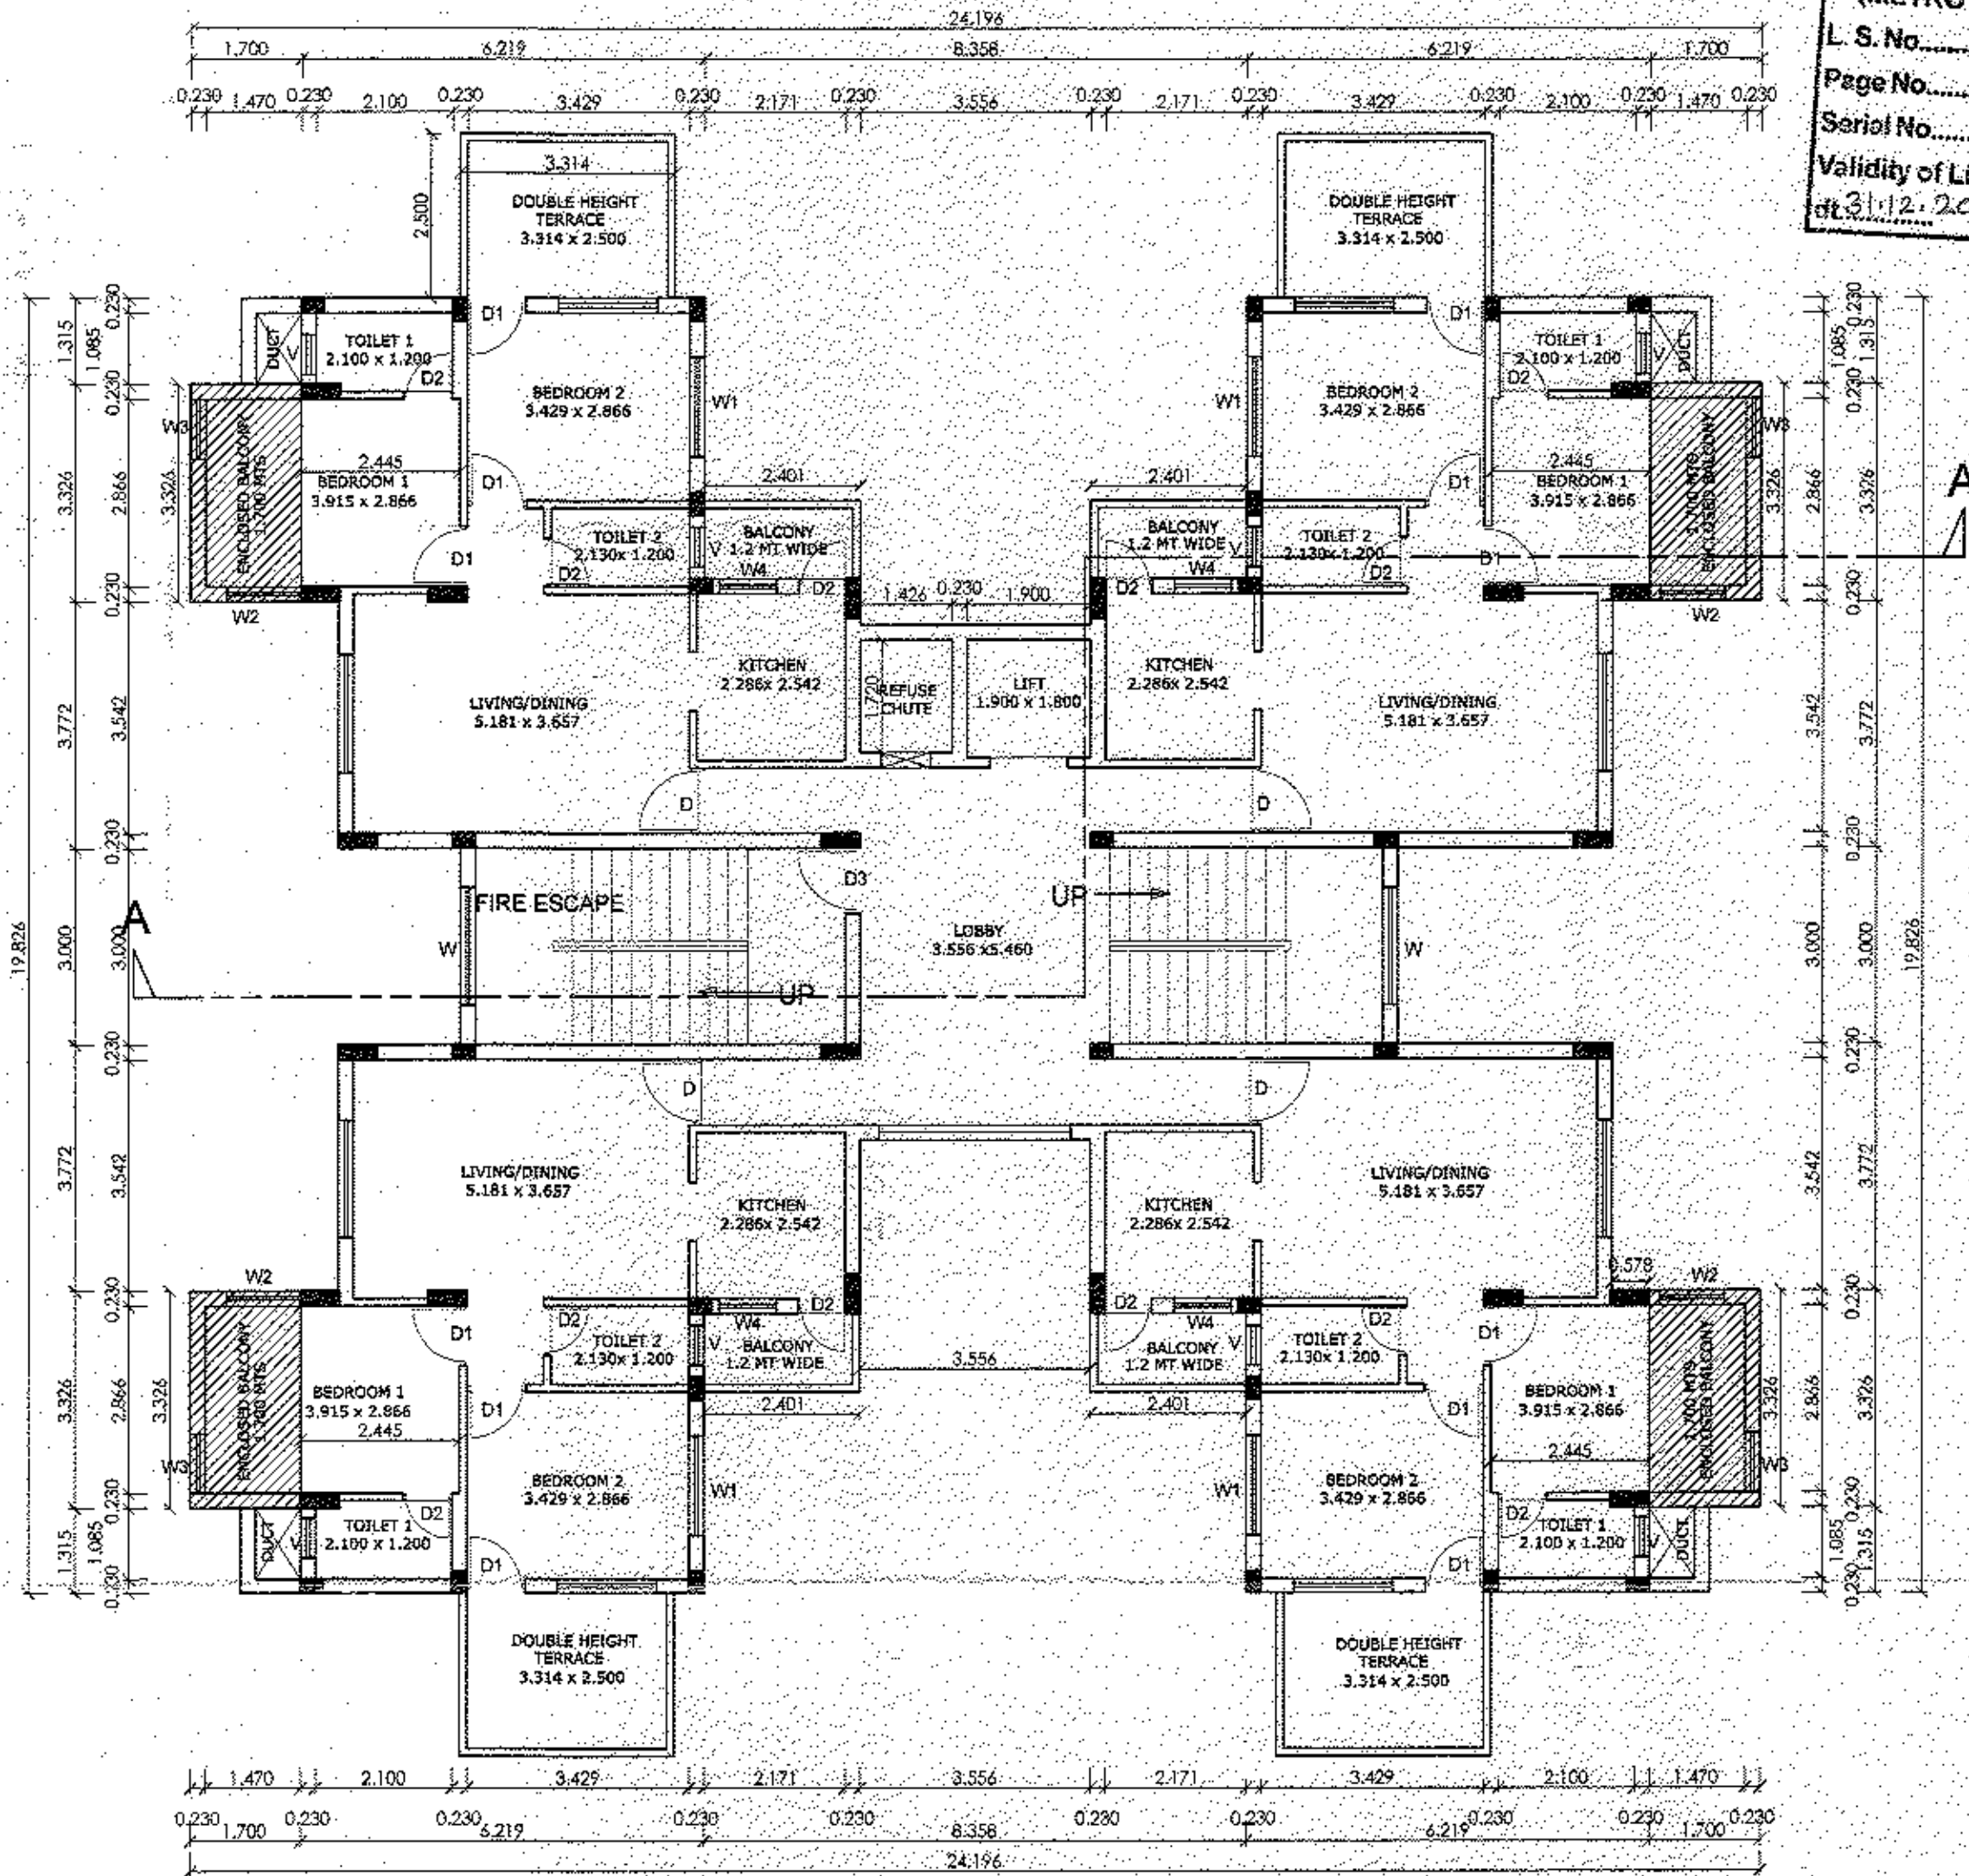
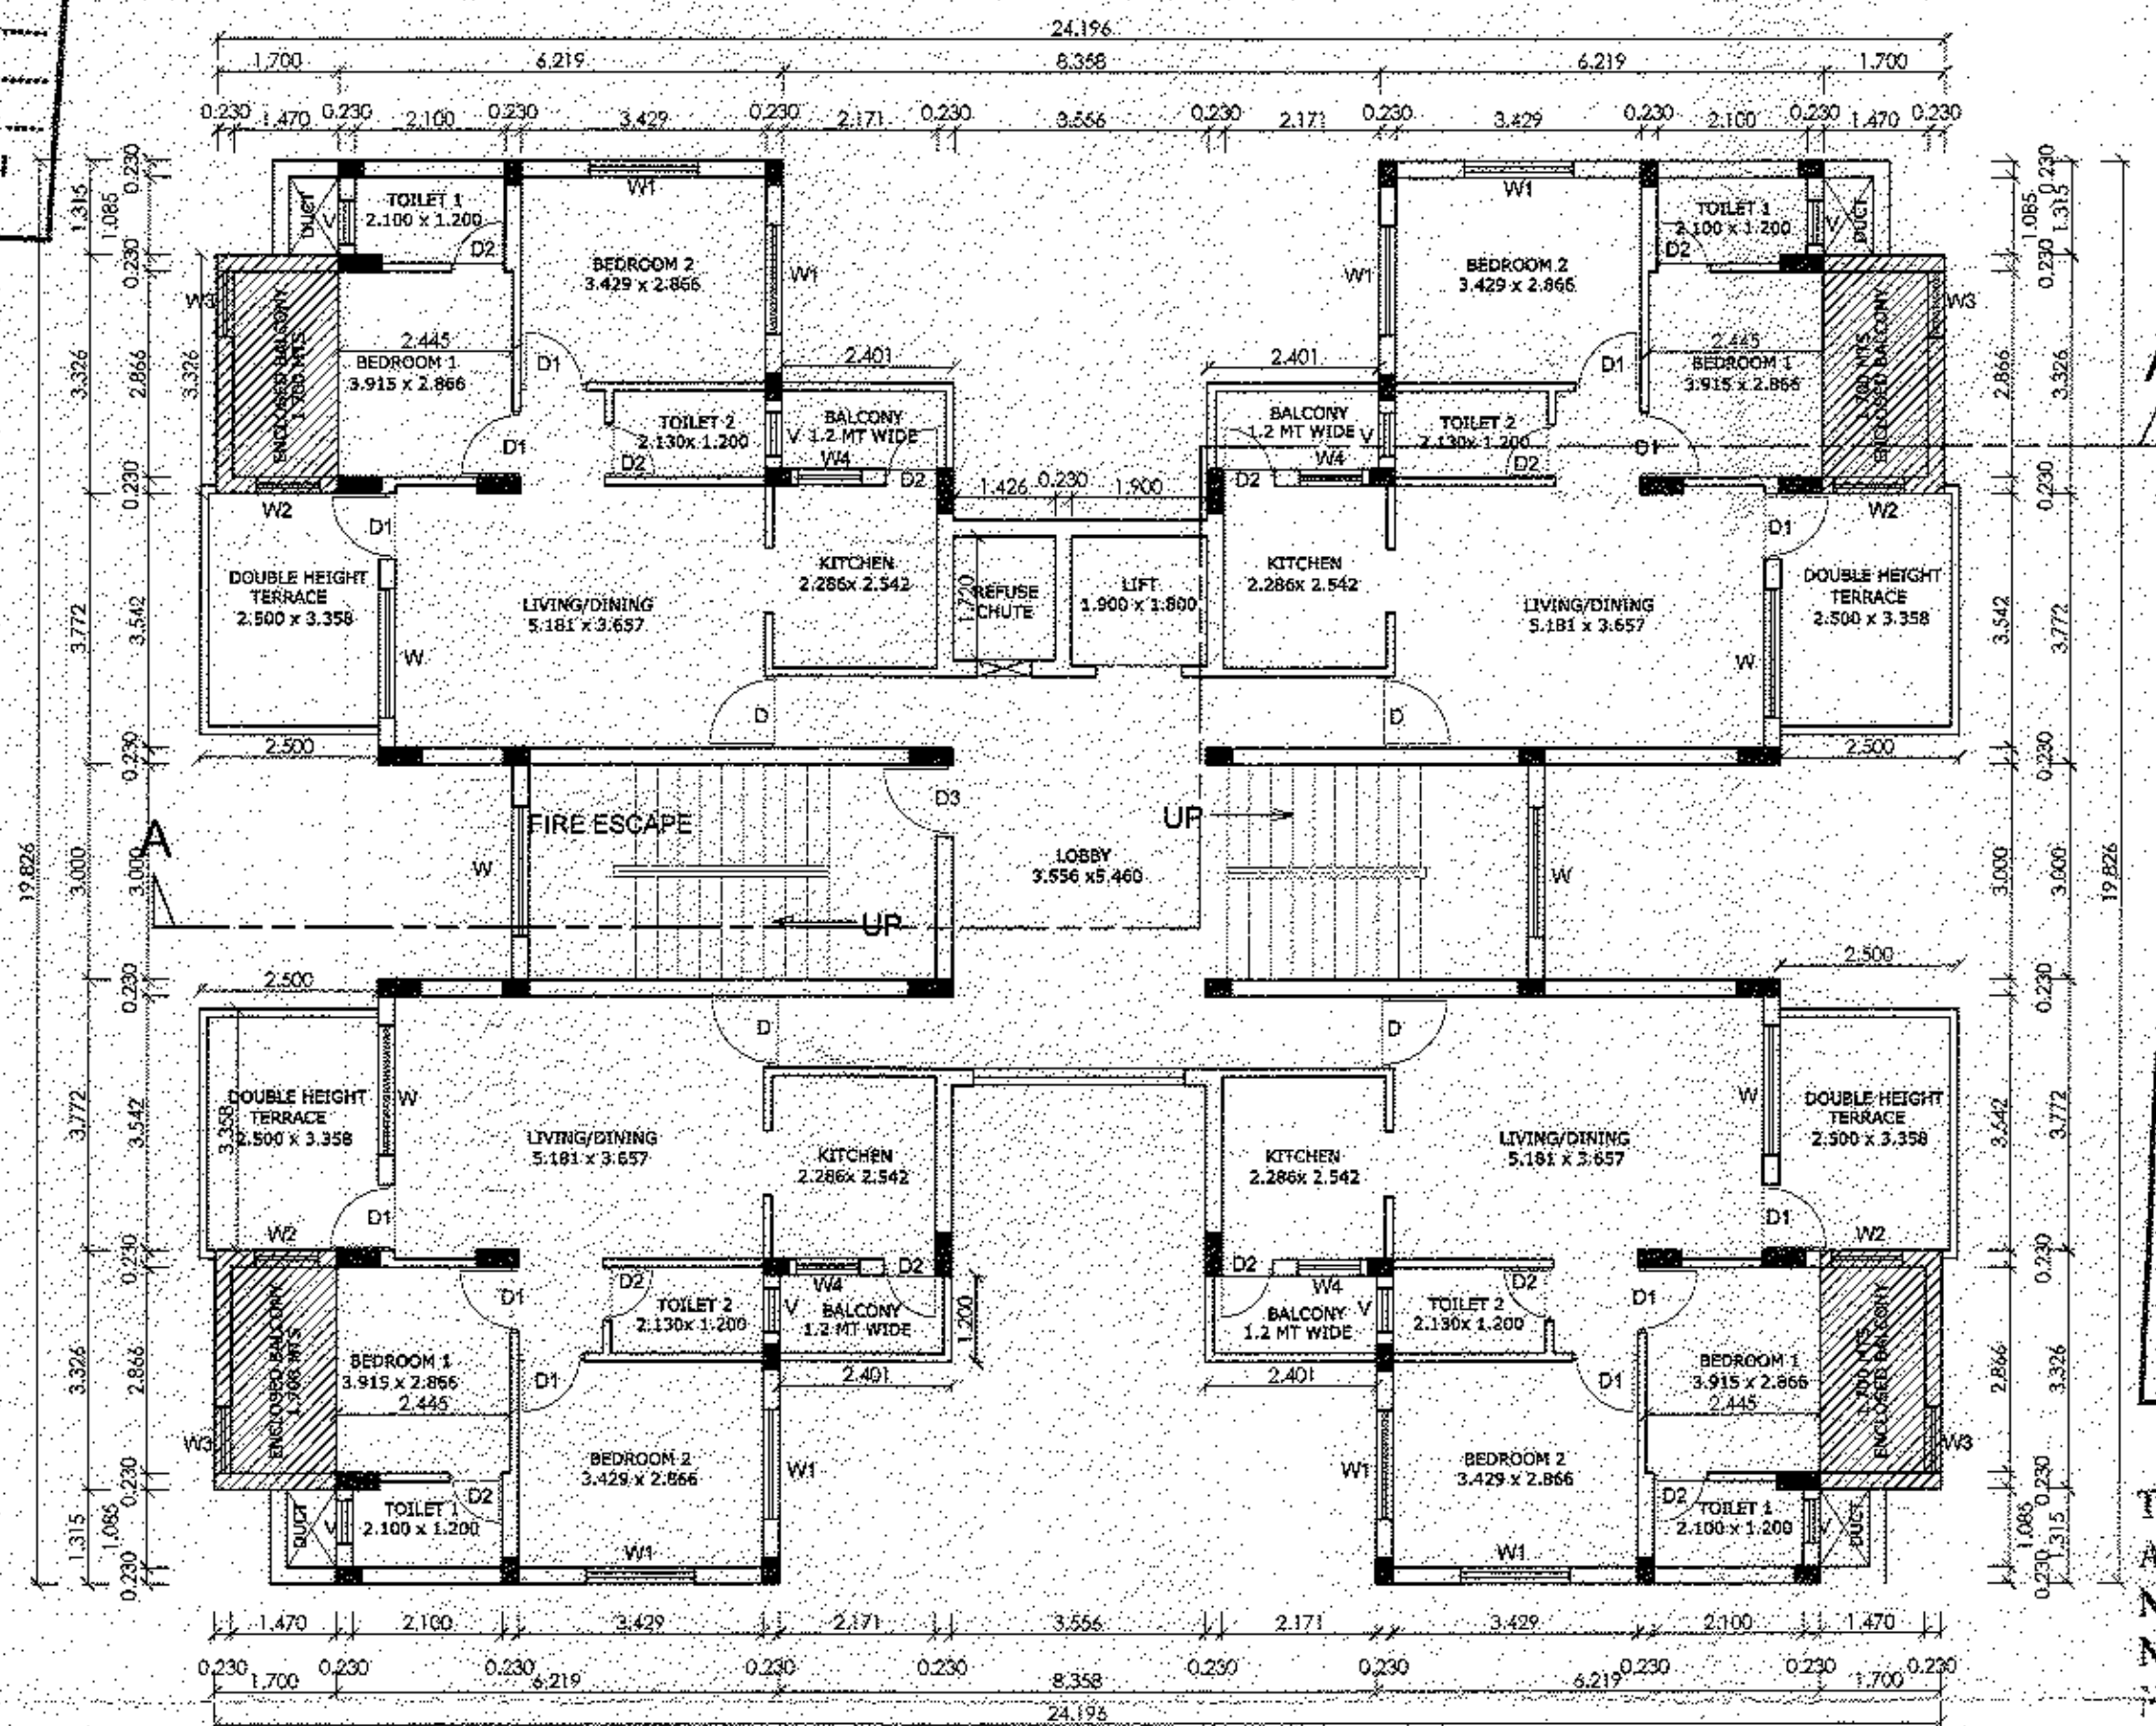
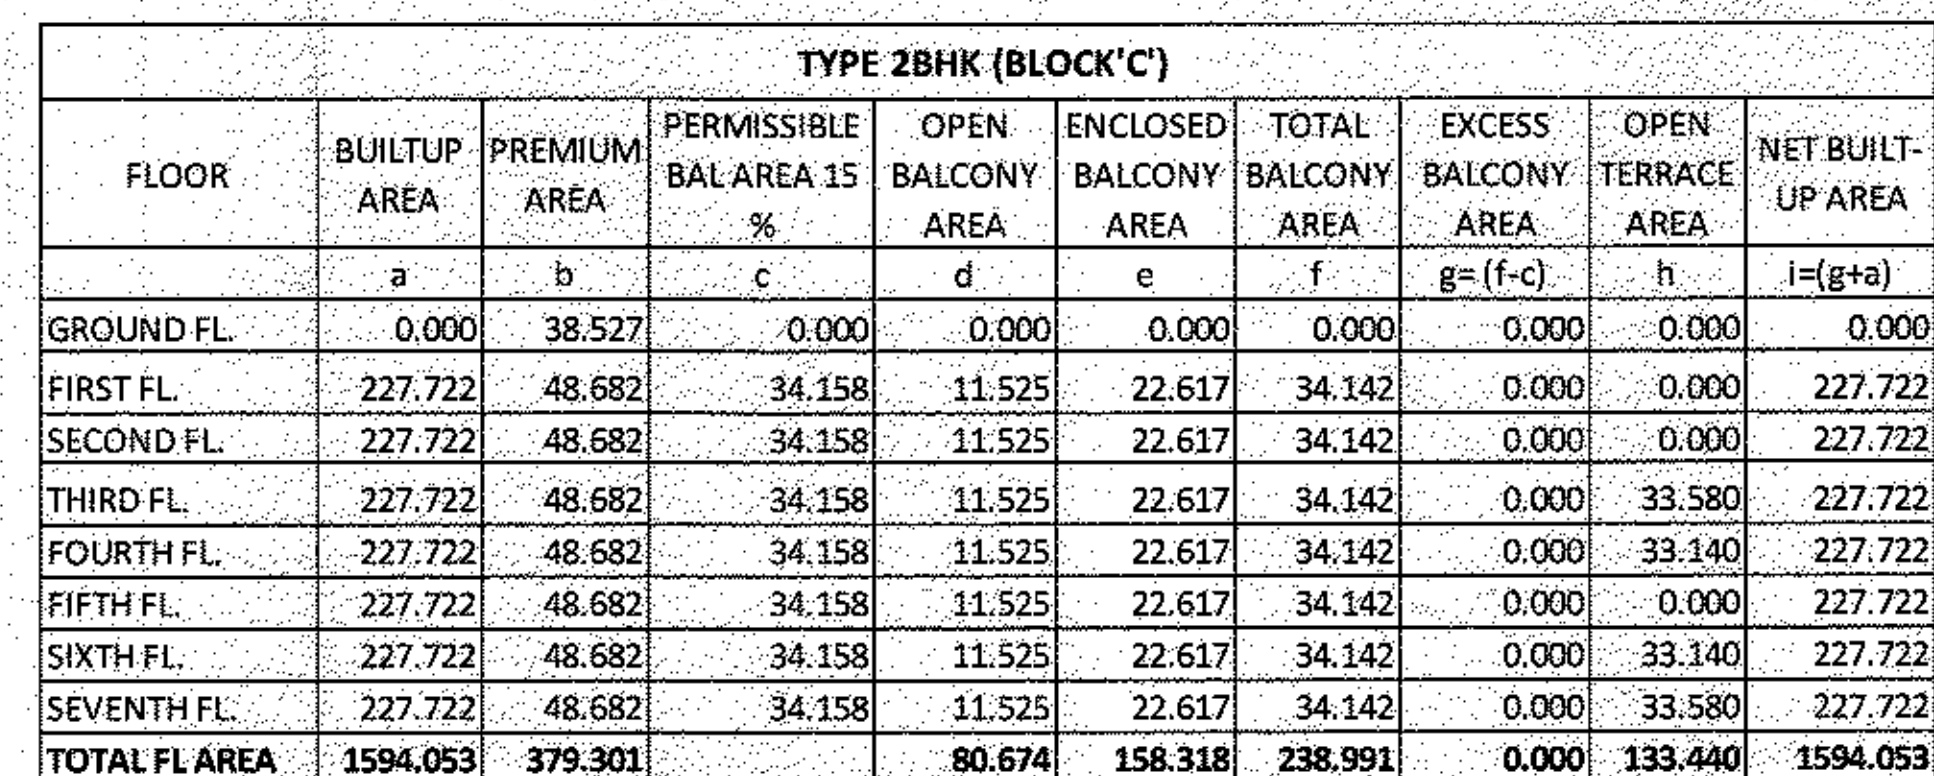


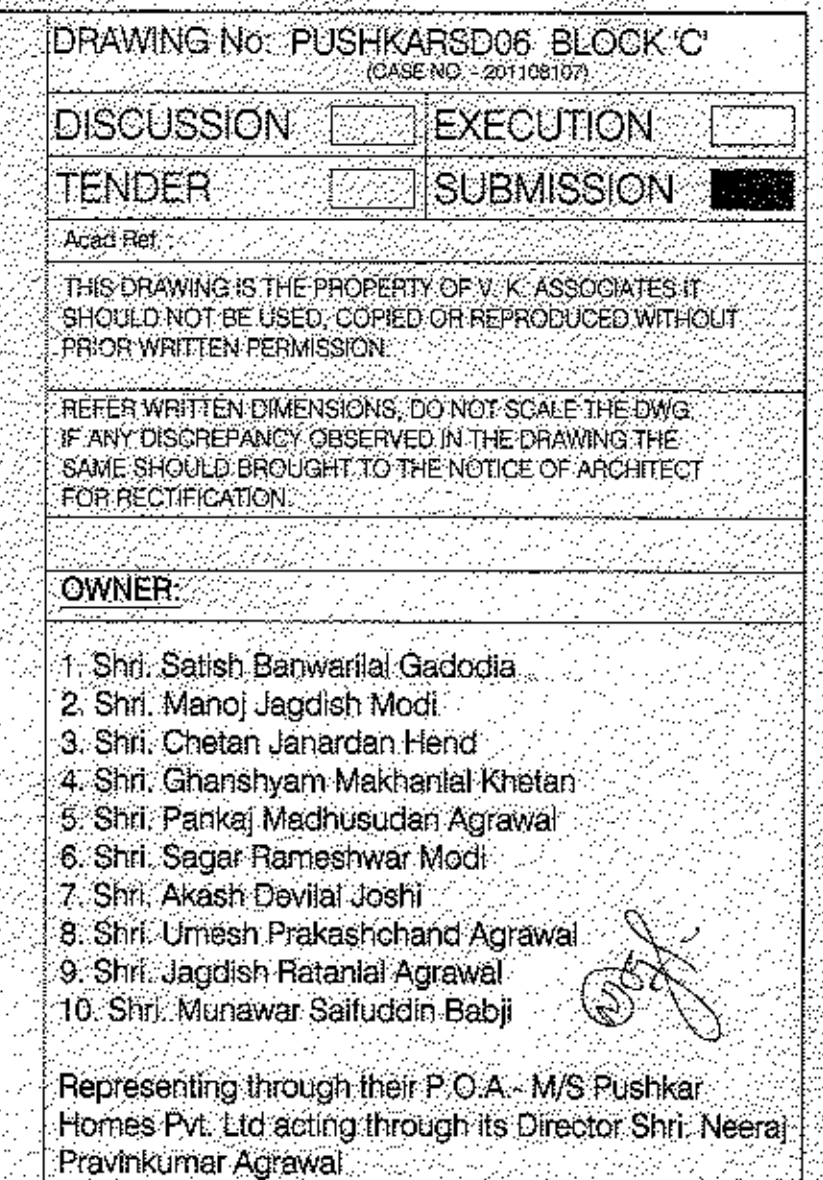

THIRD AND SEVENTH FLOOR PLAN BLOCK C
(4X2= 8 UNITS) SCALE-1:100

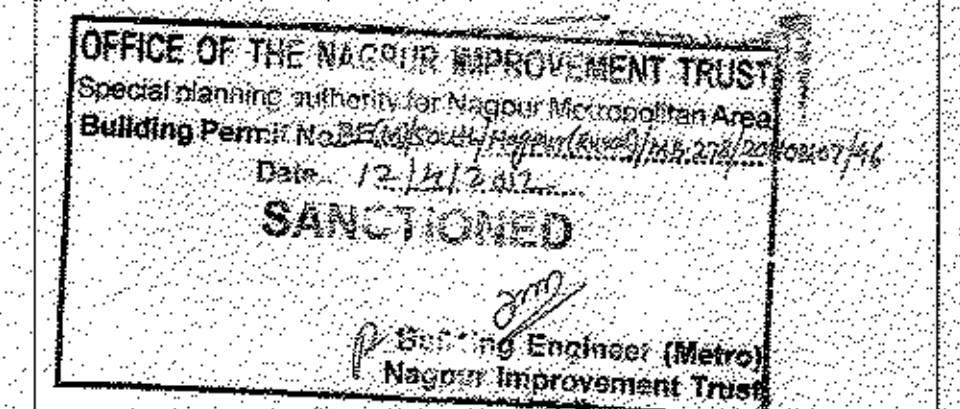


This sanction is subject to conditions mentioned in Agreement with N.I.T. dt. 05/05/2011
N.A.T.P. order dt. 25/10/2010
N.O. C. from Microwave Department dt. 11/11/11
N.O. C. from A.P. Electricity dt. 102/1/2012
Necessary arrangements for rainwater harvesting & Solar Water Heater System shall be done
Necessary arrangement for rain water harvesting shall be done.

SCHEDULE FOR OPENINGS		
M/KD	SIZE	PARTICULARS
D	1.050 X 2.100	SINGLE SHUTTER T.W.FRAME DOOR
D1	0.915 X 2.100	SINGLE SHUTTER T.W.FRAME DOOR
D2	0.760 X 2.100	SINGLE SHUTTER T.W.FRAME DOOR
D3	1.200 X 2.100	SINGLE SHUTTER M.S.FRAME DOOR
V	0.760 X 0.600	ALUMINIUM GLAZED VENTILATOR
V1	0.450 X 0.850	ALUMINIUM GLAZED VENTILATOR
W	1.800 X 1.200	ALUMINIUM GLAZED WINDOW
W1	1.525 X 1.200	ALUMINIUM GLAZED WINDOW
W2	1.220 X 1.200	ALUMINIUM GLAZED WINDOW
W3	0.760 X 0.900	ALUMINIUM GLAZED WINDOW



REVISIONS	NO.	DATE	REMARKS

PROJECT:	
PROPOSED GROUP HOUSING SCHEME AT KH.No. 182 M2 AT BORKHEDI, TEHSIL - NAGPUR (Gr)	

 
CLIENT	OWNER		SIGN:
			
ARCHITECT	VIRENDRA KHARE		SIGN:
REG. NO.	CA / 79 / 5142		
PROJECT A/R.			
DELT BY	BSF		
CHK- BY	VKA		SCALE: 1:300 1:200
JOB NO.	DWG NO.		DATE: 27/02/16
			11

DWG TITLE	BLOCK 'C' STILT + 7 (C)
-----------	-------------------------


V. H. ASSOCIATES
▲ ARCHITECTS ▲ PLANNERS ▲ INTERIOR DESIGNERS
PLOT NO.- 35(A), SHIVAJI NAGAR, CEMENT ROAD, NAGPUR - 10.
Phone: +91-710-2243942, 2243941, 2243940
www.vhassociates.com, E-mail: vhaan@vhaan.com

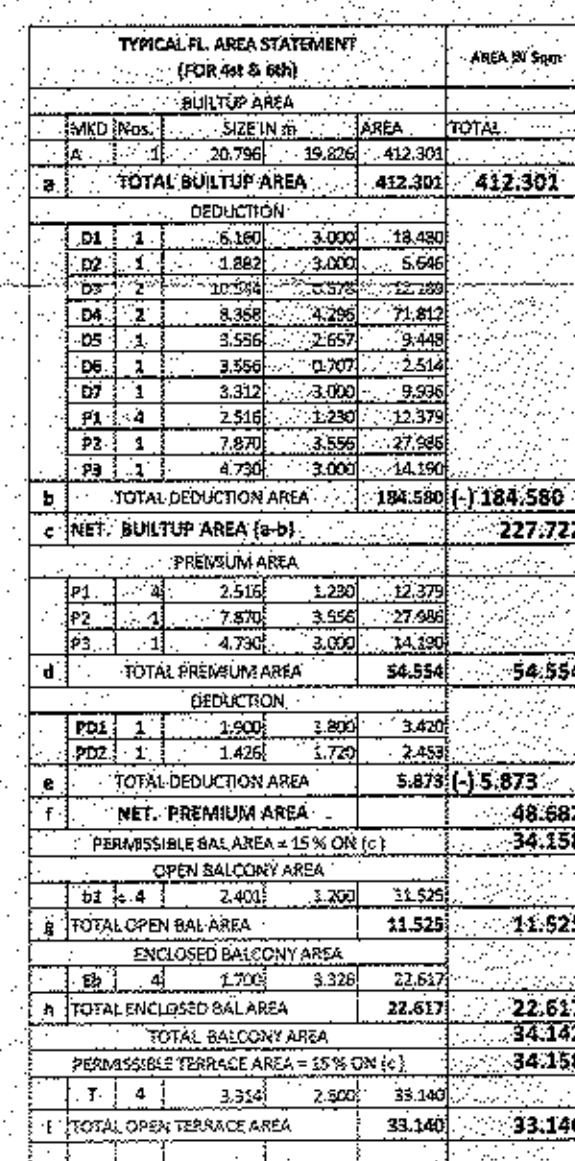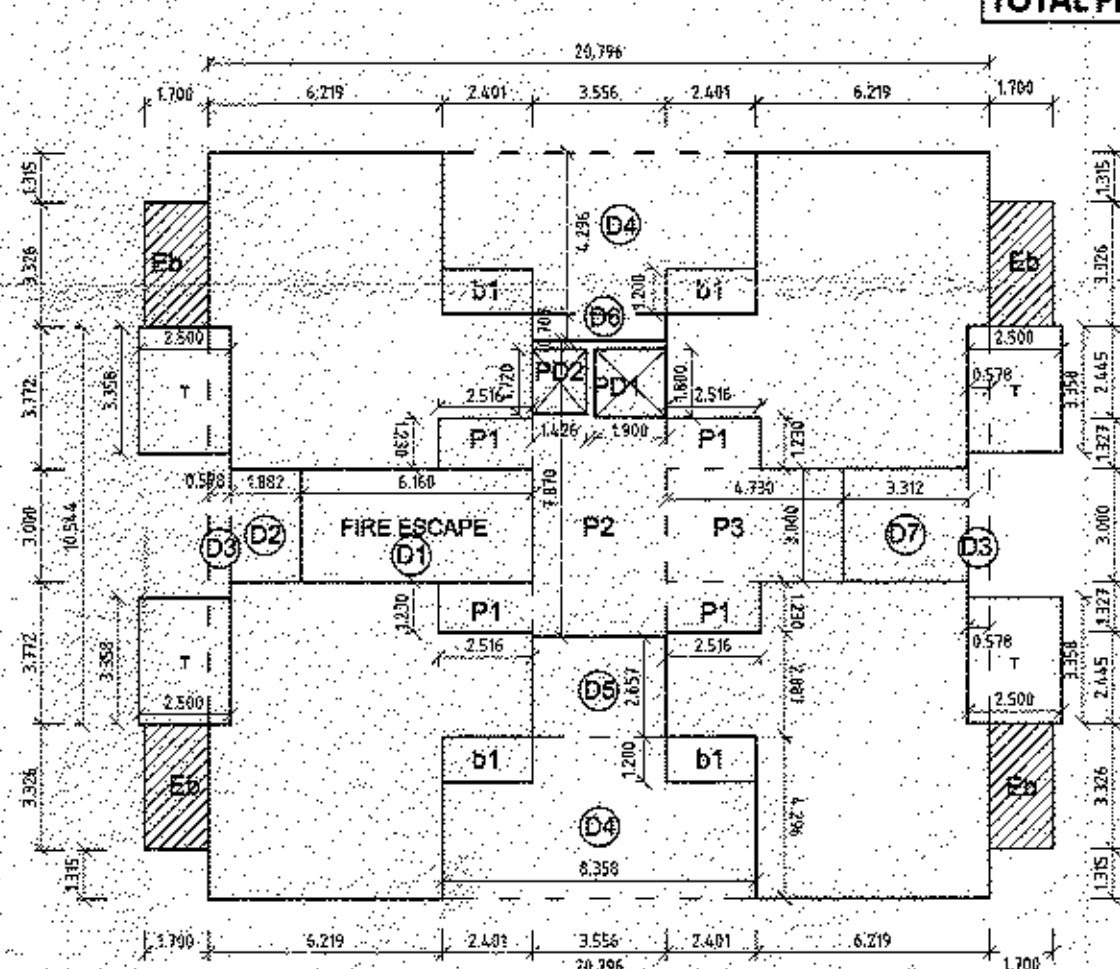

THIRD AND SEVENTH FLOOR PLAN BLOCK C
(3rd & 7th FL)
SCALE 1/200

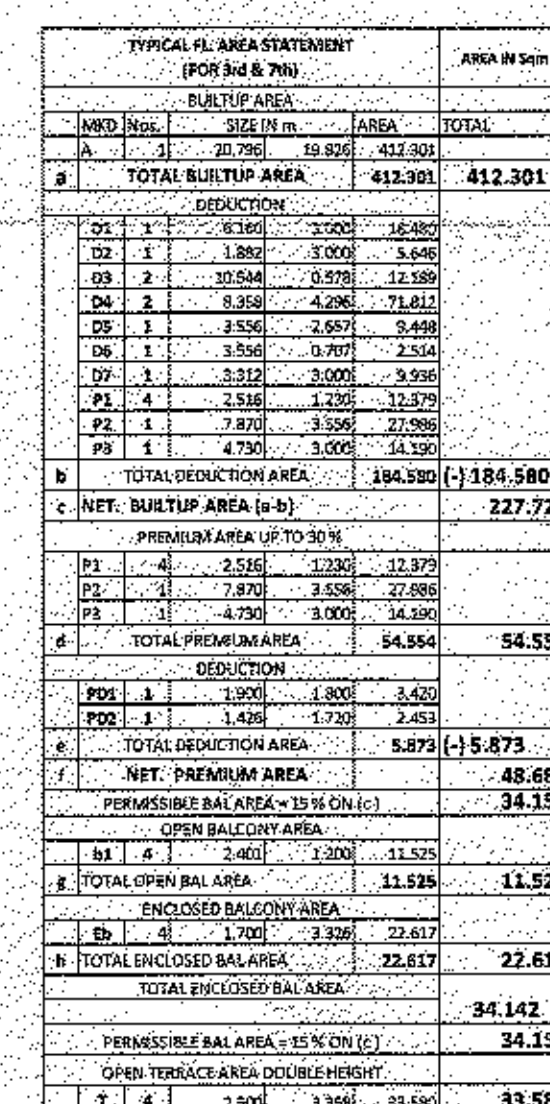

FOURTH AND SIXTH FLOOR PLAN BLOCK C
(4X2= 8 UNITS)
SCALE-1:100

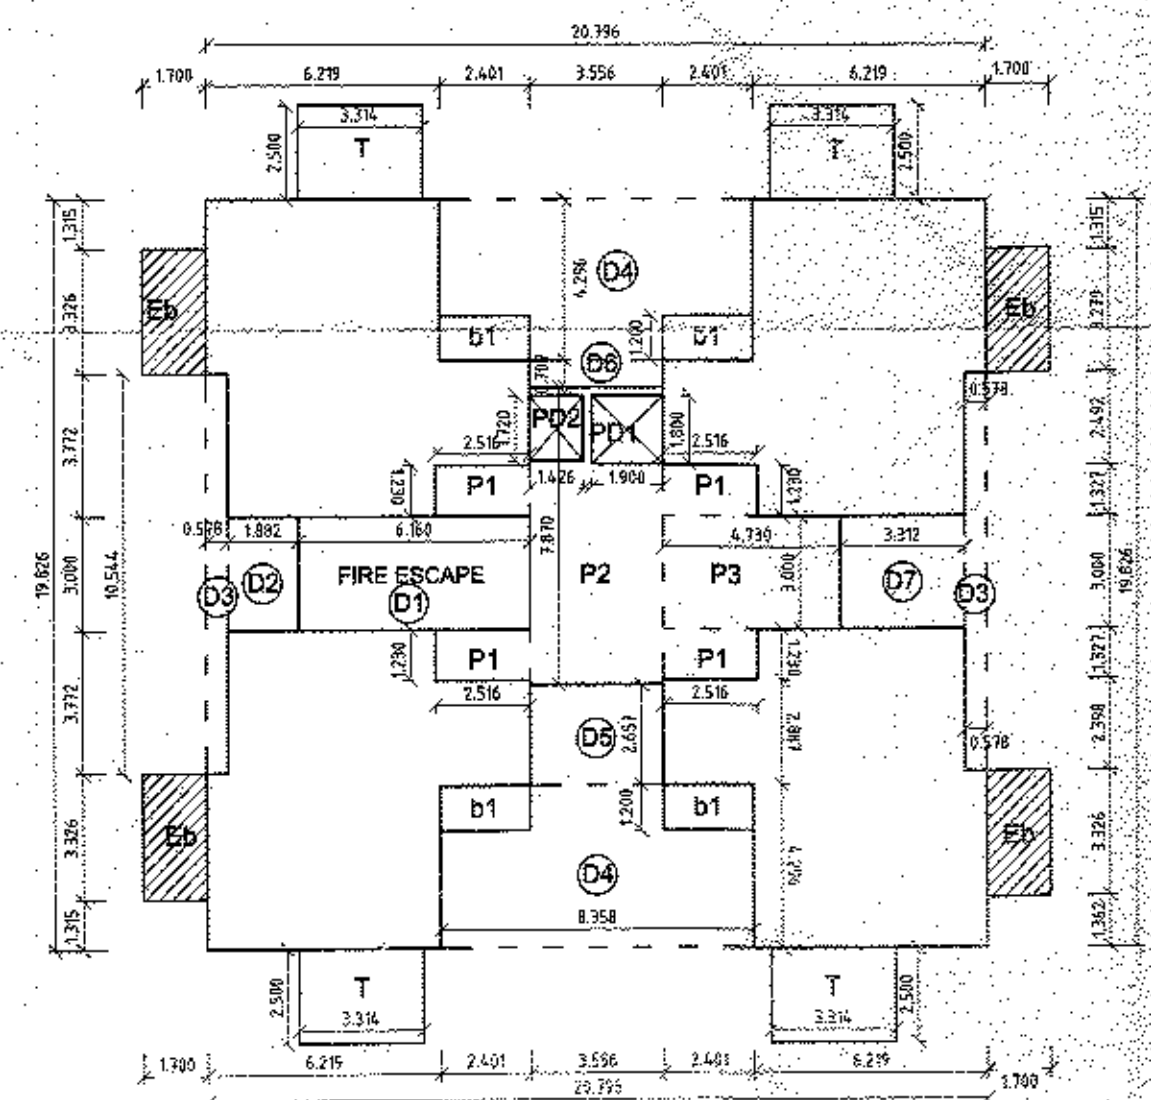

FOURTH AND SIXTH FLOOR PLAN BLOCK C
(4th & 6th FL)
SCALE 1:200