


JOB TITLE
PLAN SHOWING PROPOSED CONSTRUCTION FOR
COMMERCIAL CUM RESIDENTIAL DWELLING UNIT ON
SHEET NO.332/39-40, CITY SURVEY NO.170, KH
NO.43-44/2, P.H.NO. 34-A, HOUSE NO. 2230, WARD
NO.21, MOUZA -WATHODA,TAH-DIST- NAGPUR


BELONG TO
M/S KUKREJA INFRASTRUCTURES, THROUGH PARTNER
SHRI SHRAVAN GHANSHYAMDAS KUKREJA.

SCHEDULE OF OPENINGS :

CODE	SIZE	SILL LVL.	L.T. LVL.	REMARKS
W	1800 x 1200	900	2100	T.W. GLAZED WINDOW
W1	1500 x 1200	900	2100	T.W. GLAZED WINDOW
W2	1200 x 1050	1050	2100	T.W. GLAZED WINDOW
W3	1000 x 900	1050	2100	T.W. GLAZED WINDOW
V1	600x 750	-----	2100	LOVERED VENTILATOR
D1	1000 x 2100	-----	2100	T.W. DOOR
D2	900 x 2100	-----	2100	T.W. DOOR
D3	750 x 2100	-----	2100	T.W. DOOR

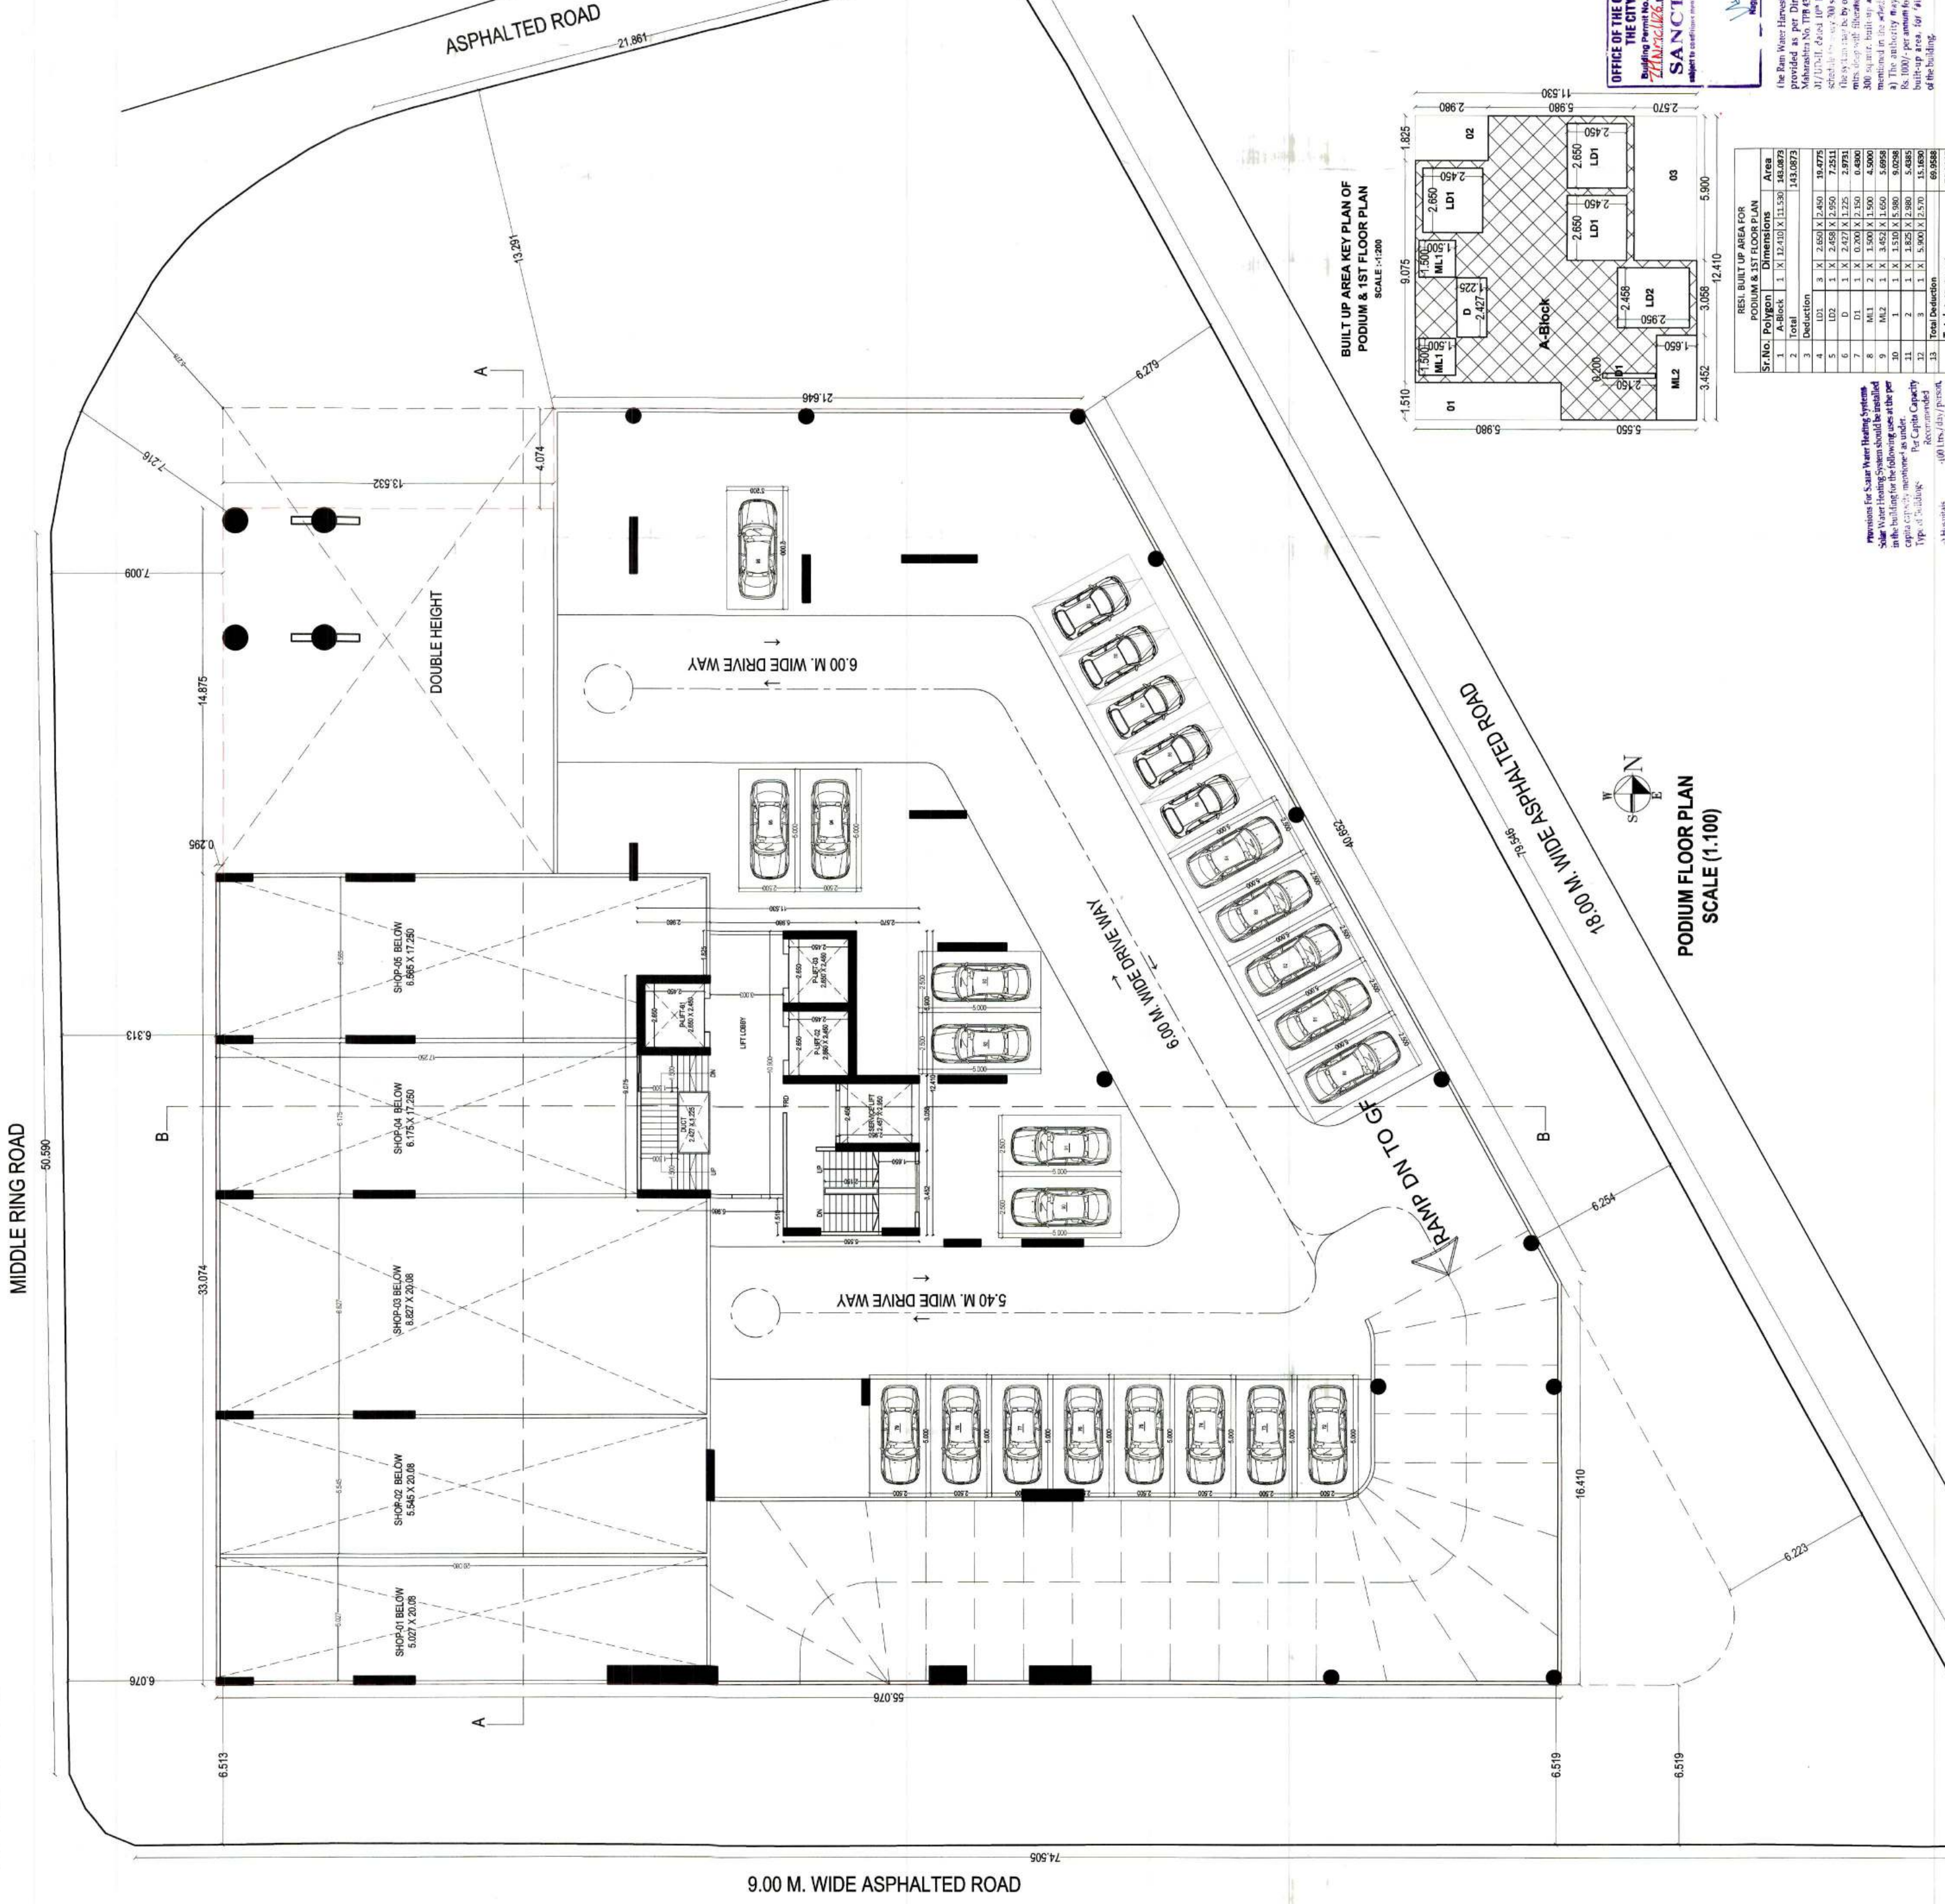

BUILT UP AREA KEY PLAN OF
PODIUM & 1ST FLOOR PLAN
SCALE: 1:200

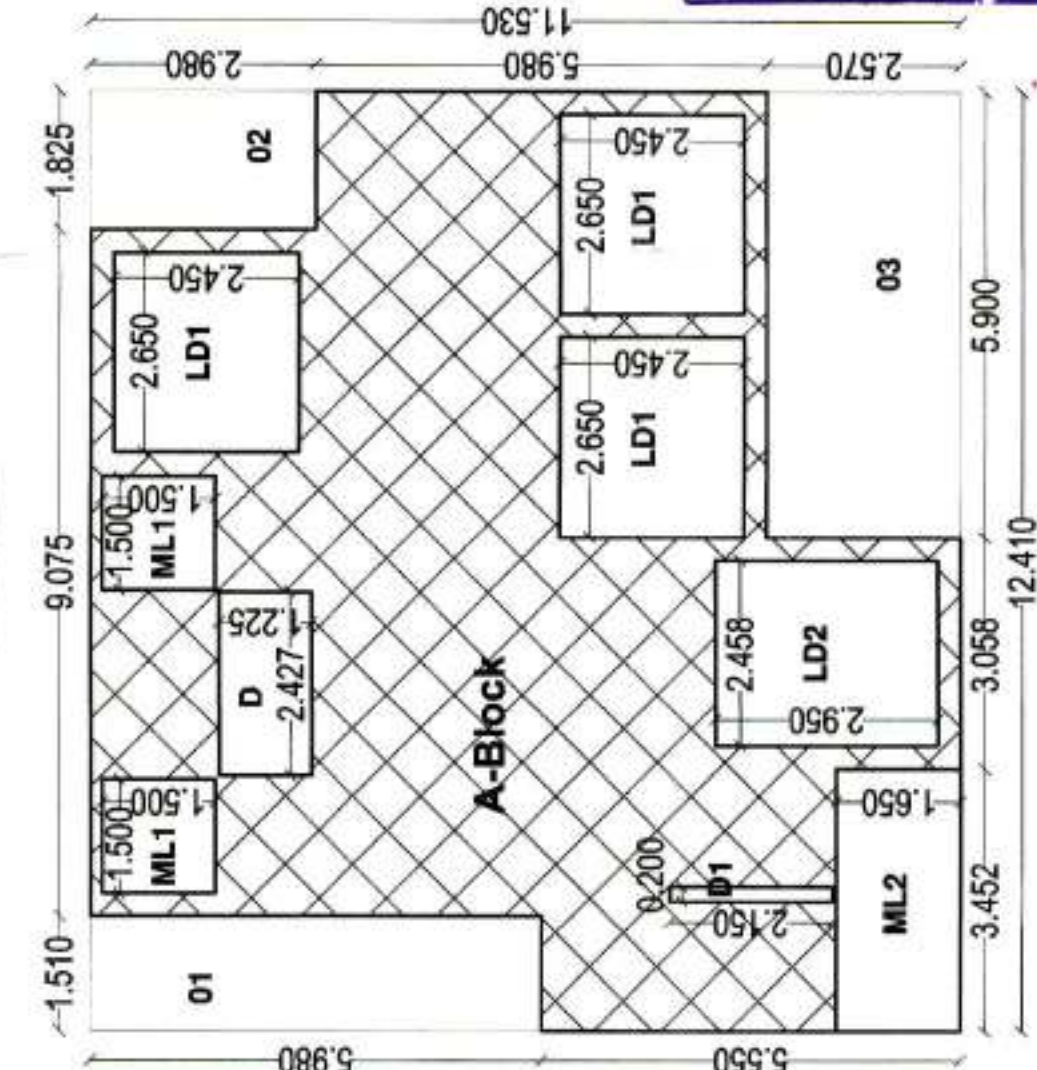

RES. BUILT UP AREA FOR PODIUM & 1ST FLOOR PLAN			
Sr.No.	Polygon	Dimensions	Area
1	A-Block	1 X 12.410 X 11.550	143.0972
2	Total		143.0972
3	Deduction		
4	ML1	3 X 3.450 X 2.650	27.225
5	ML2	3 X 2.650 X 2.650	21.0375
6	D	1 X 2.627 X 1.225	2.9731
7	D1	1 X 0.200 X 2.150	0.4300
8	ML1	2 X 3.500 X 1.500	4.5000
9	ML2	1 X 3.450 X 1.500	5.1750
10	D	1 X 3.450 X 1.500	5.1750
11	D1	1 X 3.450 X 1.500	5.1750
12	D	1 X 3.450 X 1.500	5.1750
13	Total Deduction		69.5588
14	Total	Sr.No. (2-13)	73.1285

Provision for Solar Water Heating Systems
Solar Water Heating Systems shall be installed
in the following use as the per
compliance is mentioned as under:
Type of Building Per Capita Capacity
Recommendation
3. Hospitals 100 ltr./day/person
4. Hotels 150 ltr./day/person
5. Residential 25 ltr./day/person
6. Institutional 25 ltr./day/person
7. The provision as above is not mandatory
8. The provision as above is not mandatory
9. The provision as above is not mandatory

OFFICE OF THE CORPORATION OF
THE CITY NAGPUR
Building Permit No. 182/1900/2021
THANALU Date: 16.10.21
SANCTIONED
Subject to specifications mentioned in the building plan.

The Rain Water Harvesting is required to be
provided as per Direction of Govt. of
Maharashtra No. 178/2007/213 CR-2017
dated 16.08.2017. The Rain Water Harvesting
system shall be provided in the building
with a capacity of 300 litres per person
per day. The Rain Water Harvesting system
shall be provided in the building with a
capacity of 300 litres per person per day.
The Rain Water Harvesting system shall be
provided in the building with a capacity of
300 litres per person per day. The Rain
Water Harvesting system shall be provided
in the building with a capacity of 300
litres per person per day. The Rain Water
Harvesting system shall be provided in the
building with a capacity of 300 litres per
person per day. The Rain Water Harvesting
system shall be provided in the building
with a capacity of 300 litres per person
per day. The Rain Water Harvesting system
shall be provided in the building with a
capacity of 300 litres per person per day.

REFERENCE :
PLOT BOUNDARY SHOWN IN THIS
PROPOSED CONSTRUCTION SHOWN IN THIS
WORK TO BE DEMOLISHED SHOWN THIS

CCA REG. NO. 173981
SCALE: 1:100 & 1:200
DATE: 10-04-2021
N.T. REG. NO. 7445
N.T. REG. NO. 7445
RELT. BY: BK
CHECKED BY: BK

Note - ALL DIMENSIONS ARE IN MM.
SUBMISSION DWG.

Architect's Sign Client's Sign

Ar. LOKESH KADU
CA/2007/38351
THROUGH PARTNER
SHRI SHRAVAN GHANSHYAMDAS KUKREJA
Ar. LOKESH W. KADU
CA. No. : CA / 2007 / 3981

Ar. LOKESH W. KADU
Architecture, Planning, Interiors
Block No. 11, 11A, 12, A Wing, LB Wing, Mangalwar Complex,
Near Bhamare Chaudhari Chowk, Nagpur
Cell: 91 982072384, 91 977862628
mail id: lokeshwdesign@gmail.com, web: www.lokeshwdesign.in

DESIGN