


Relatively Approved
For Fire NOCC Only
Building Engineer (West)
Nagpur Improvement Trust
L.S. No. 248
Serial No. 248
Valid Up to 31-12-2022

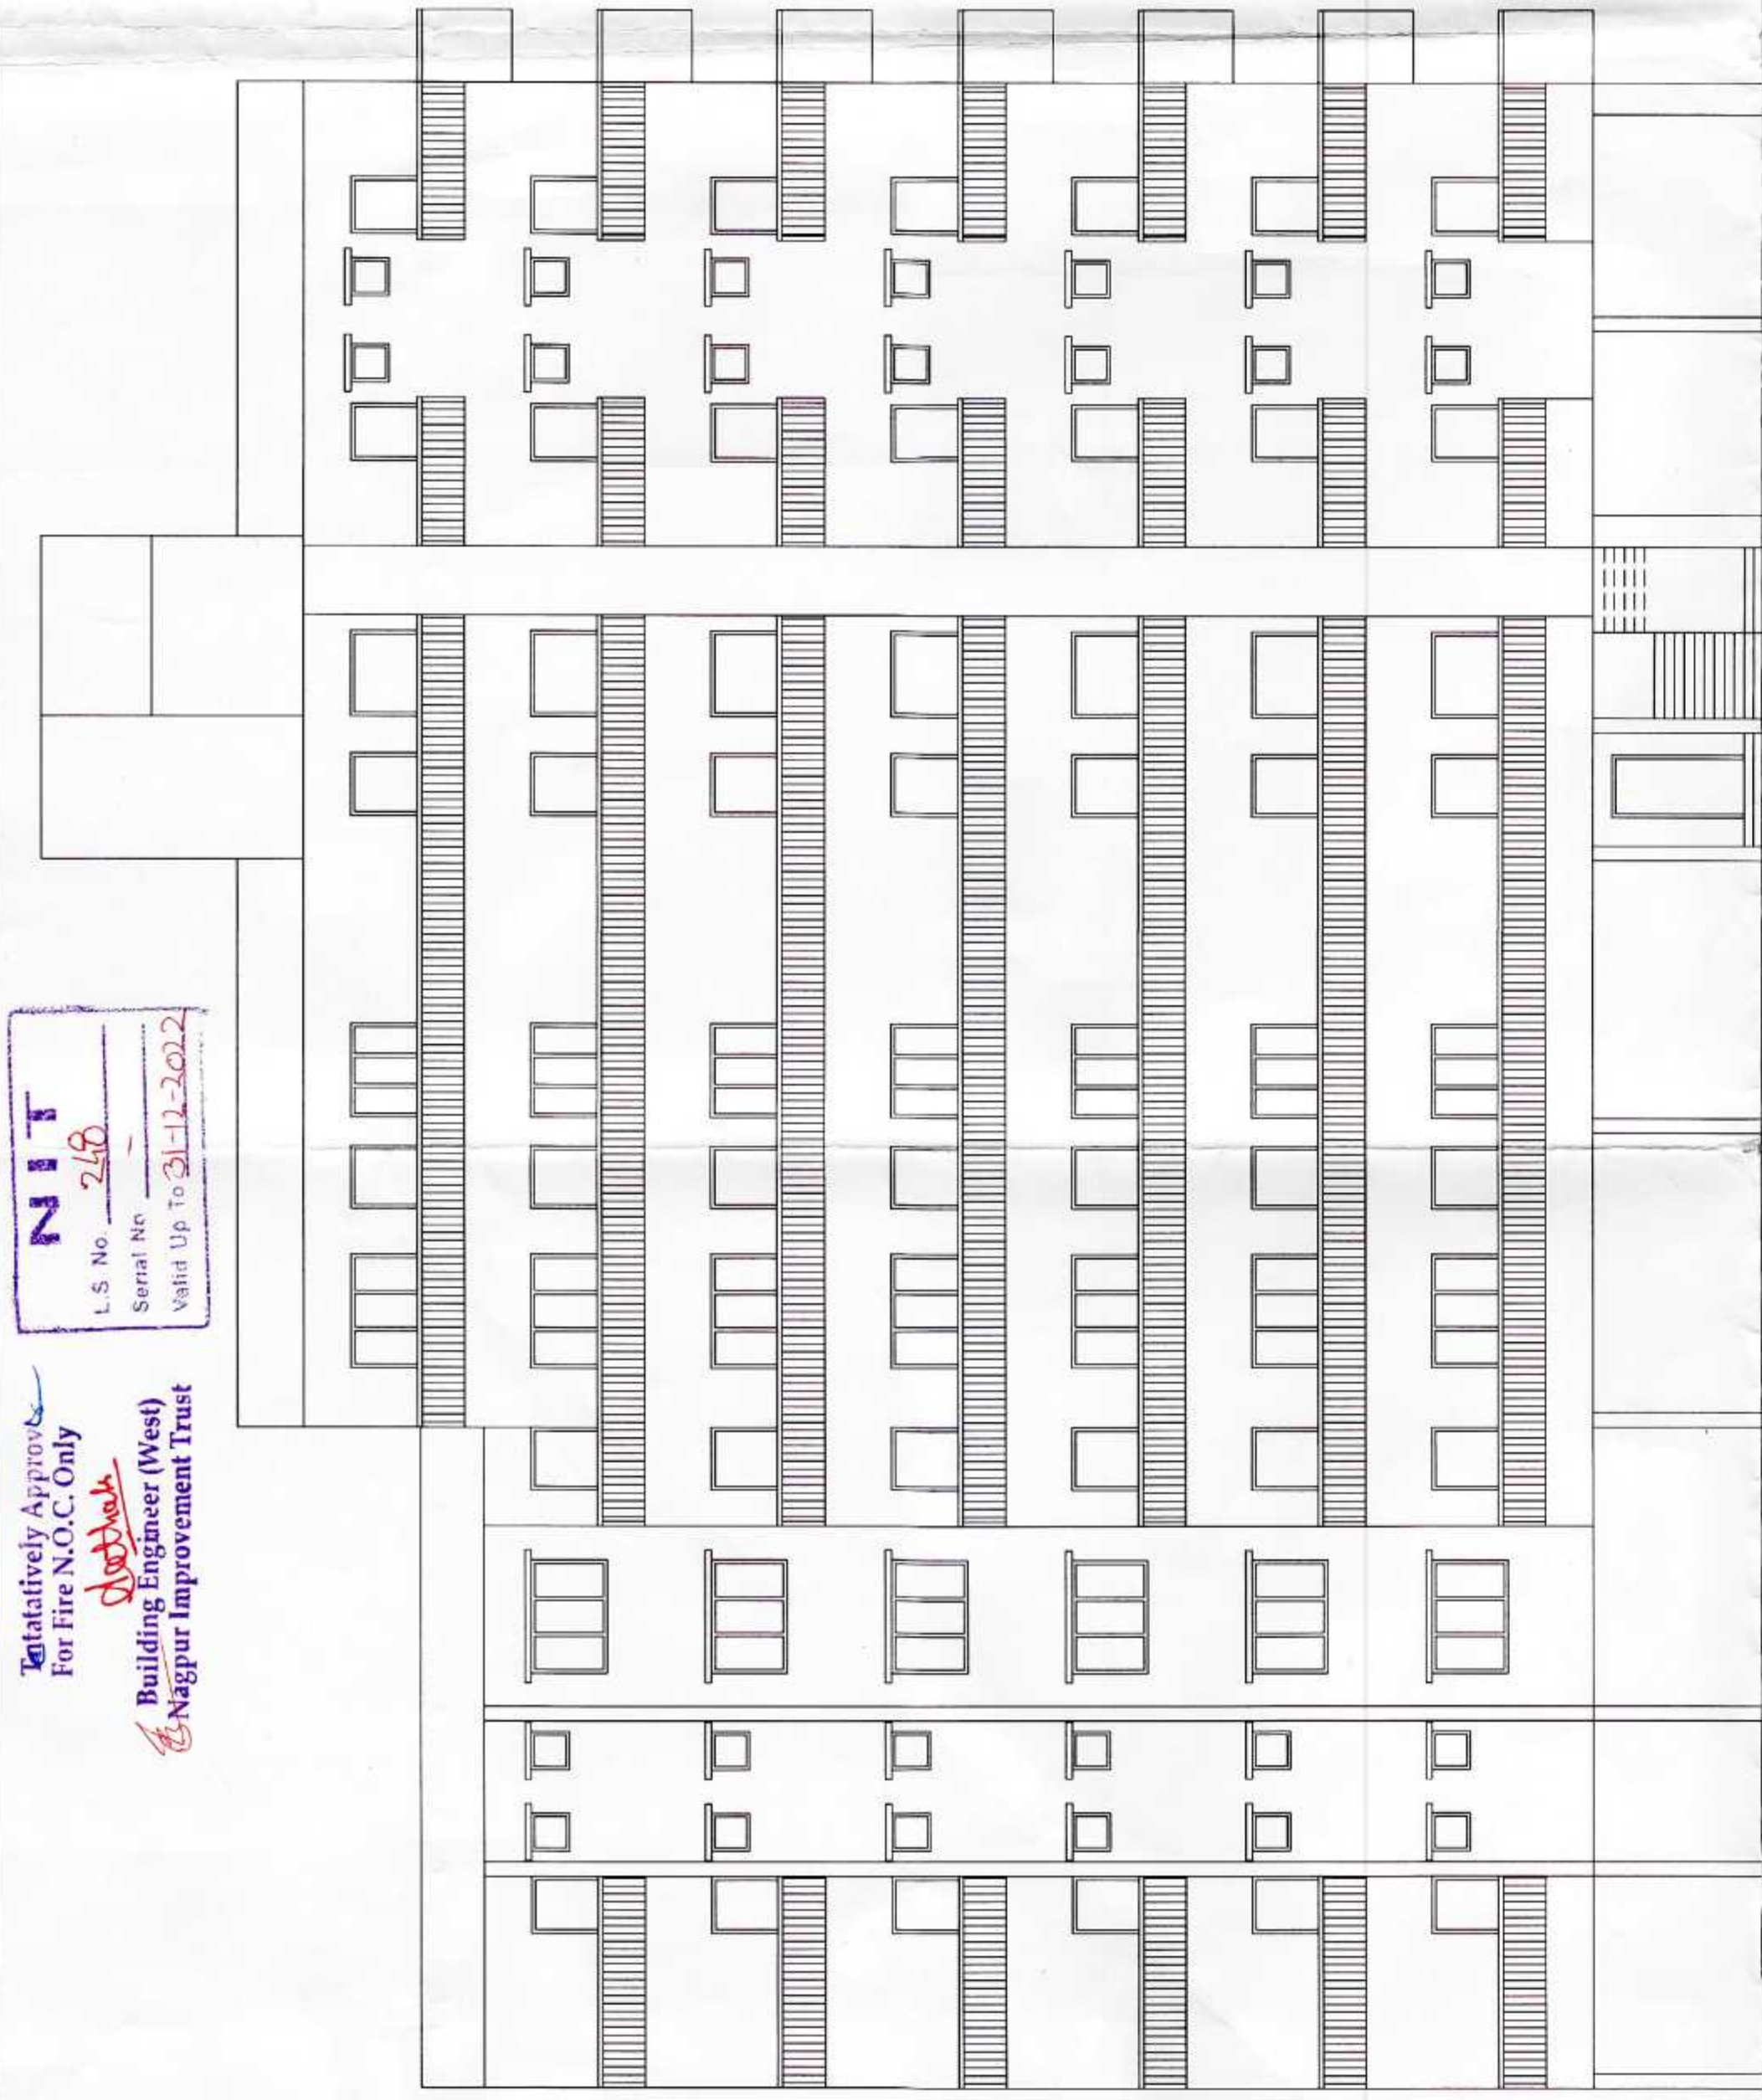

Subject to the condition as per
Regulation letter dt. 29.07.2016.


FRONT ELEVATION SCALE 1:100

ROOF RAINWATER HARVESTING SYSTEM
SHOULD BE PROVIDED WITHIN PLOT AREA




PARKING (GROUND) FLOOR PLAN SCALE 1:100

OFFICE OF THE NAGPUR IMPROVEMENT TRUST
Building Permit No. 44562/2022/108/106/356/325/25780/Decking No. 202203-576/941
Date: 19.10.2022
SANCTIONED
Building Engineer (West)
Nagpur Improvement Trust

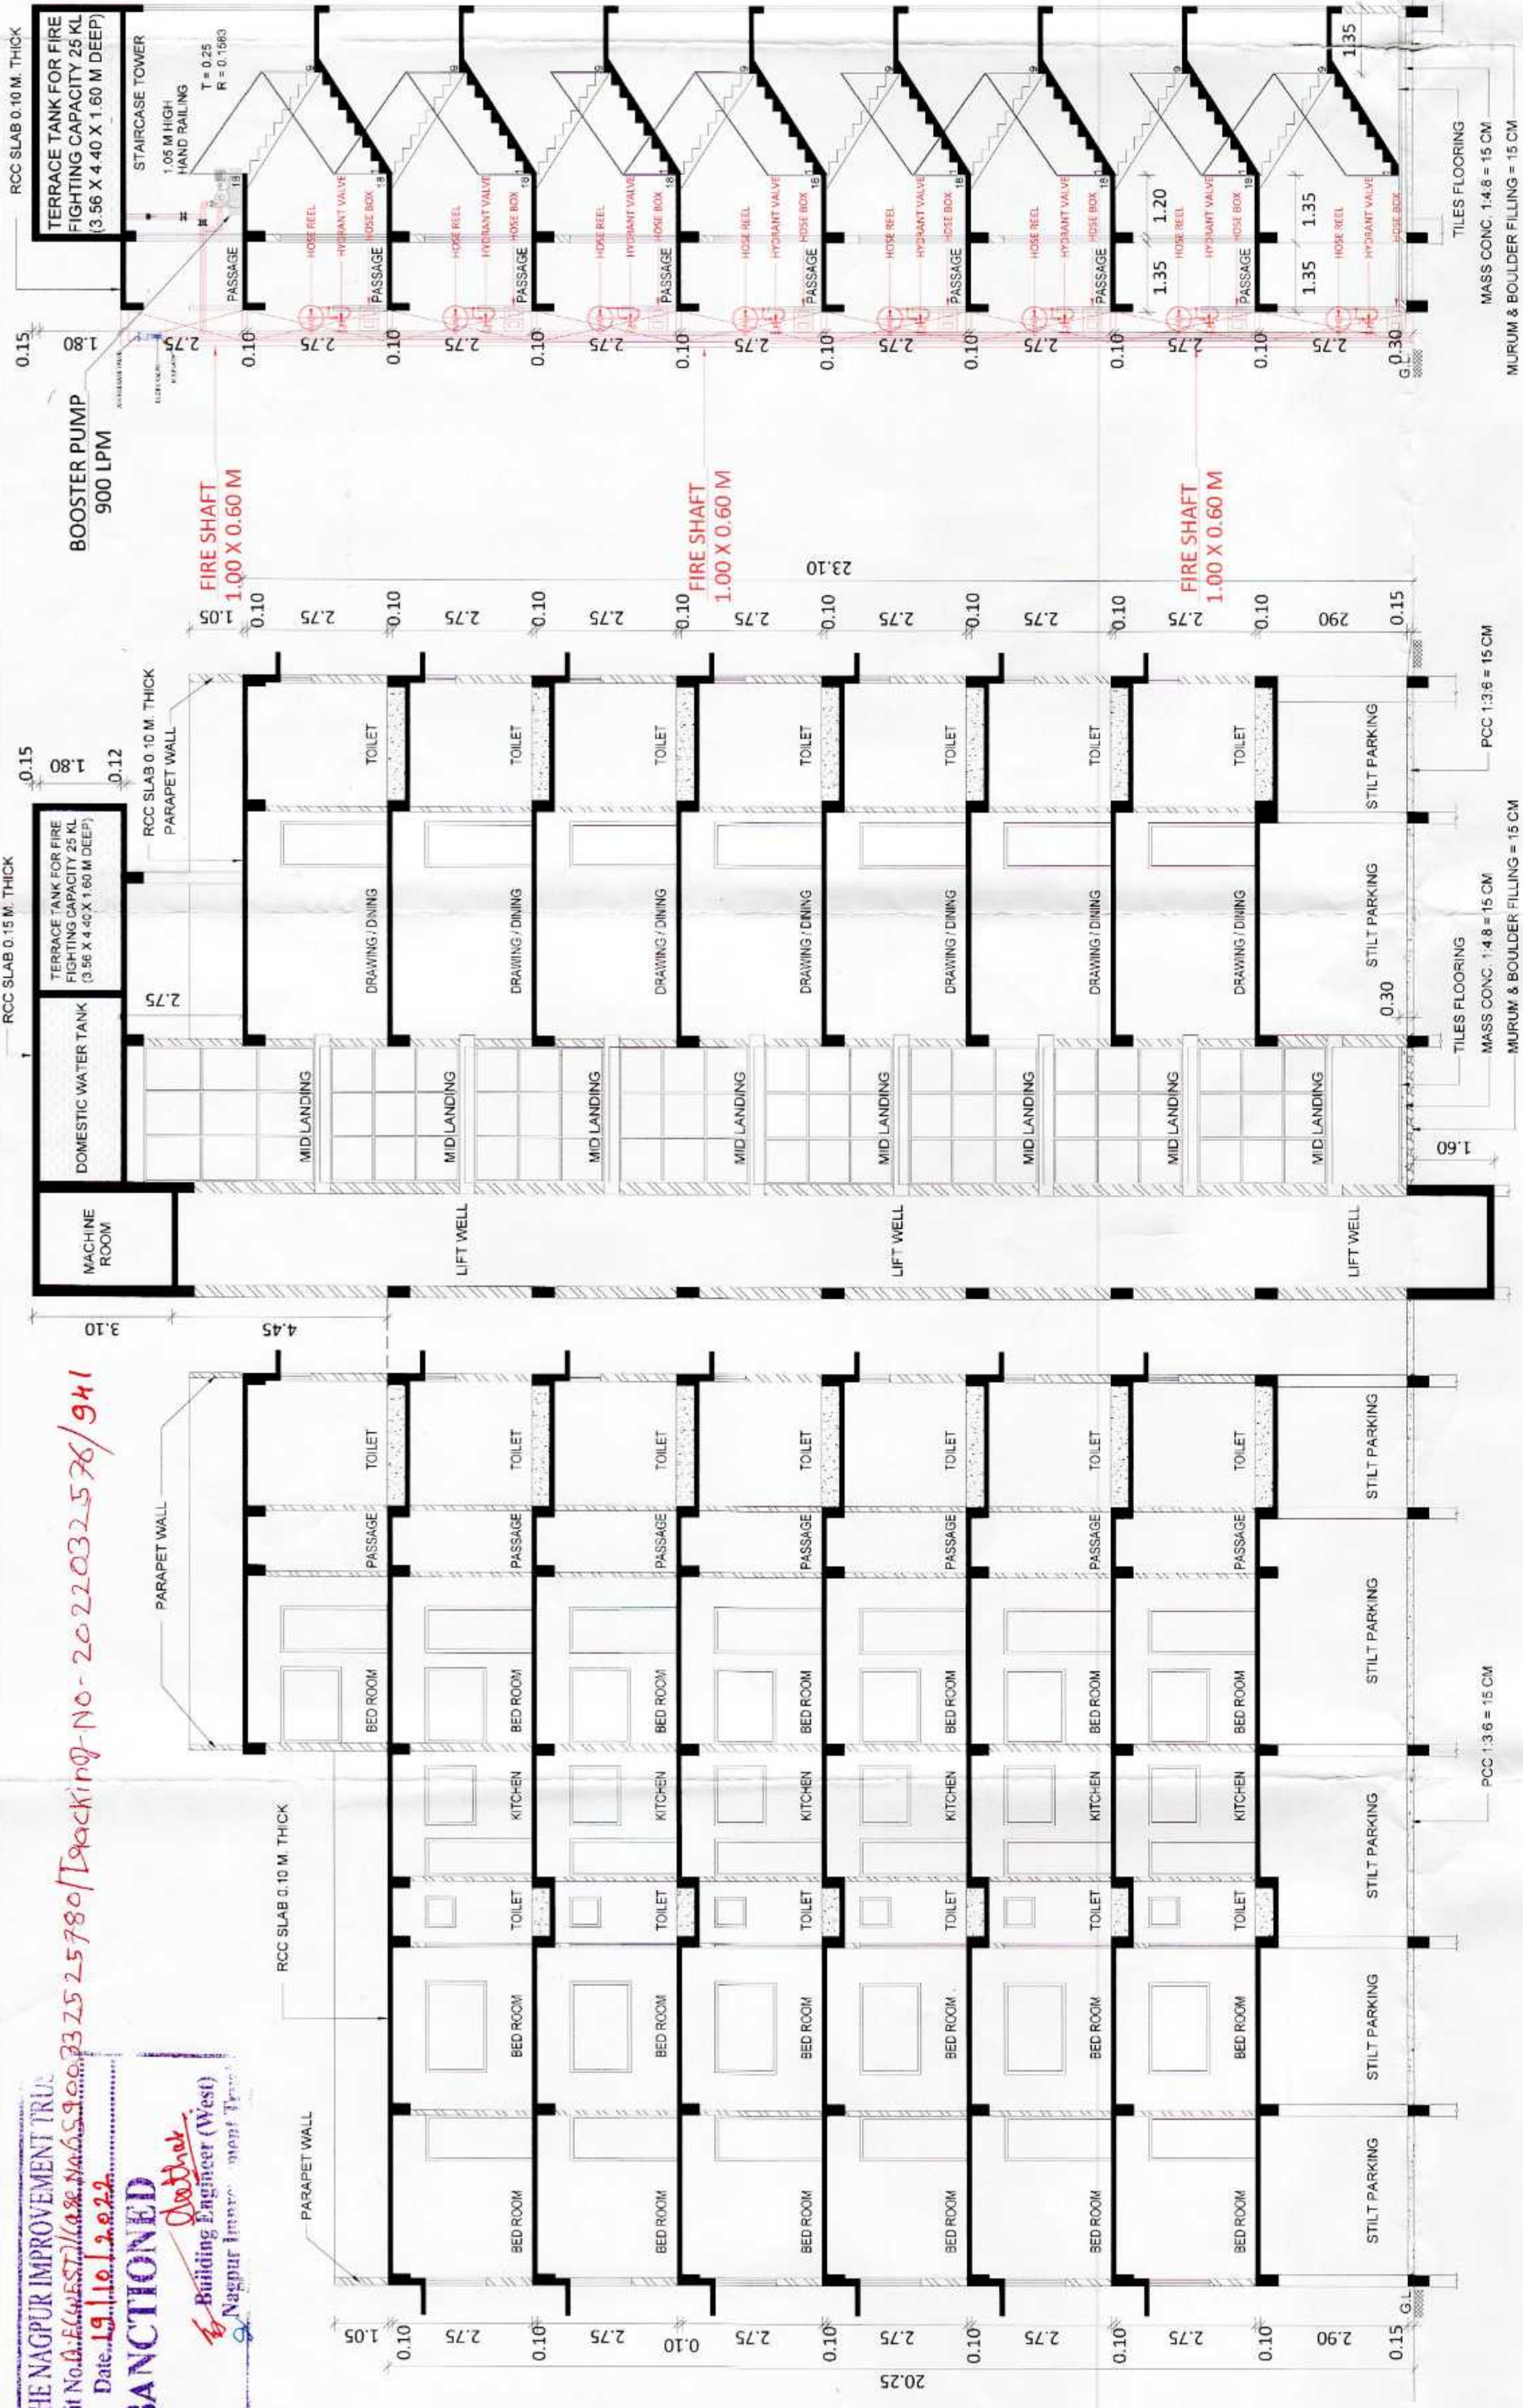

SECTION - XX SCALE 1:100

SECTION - YY SCALE 1:100

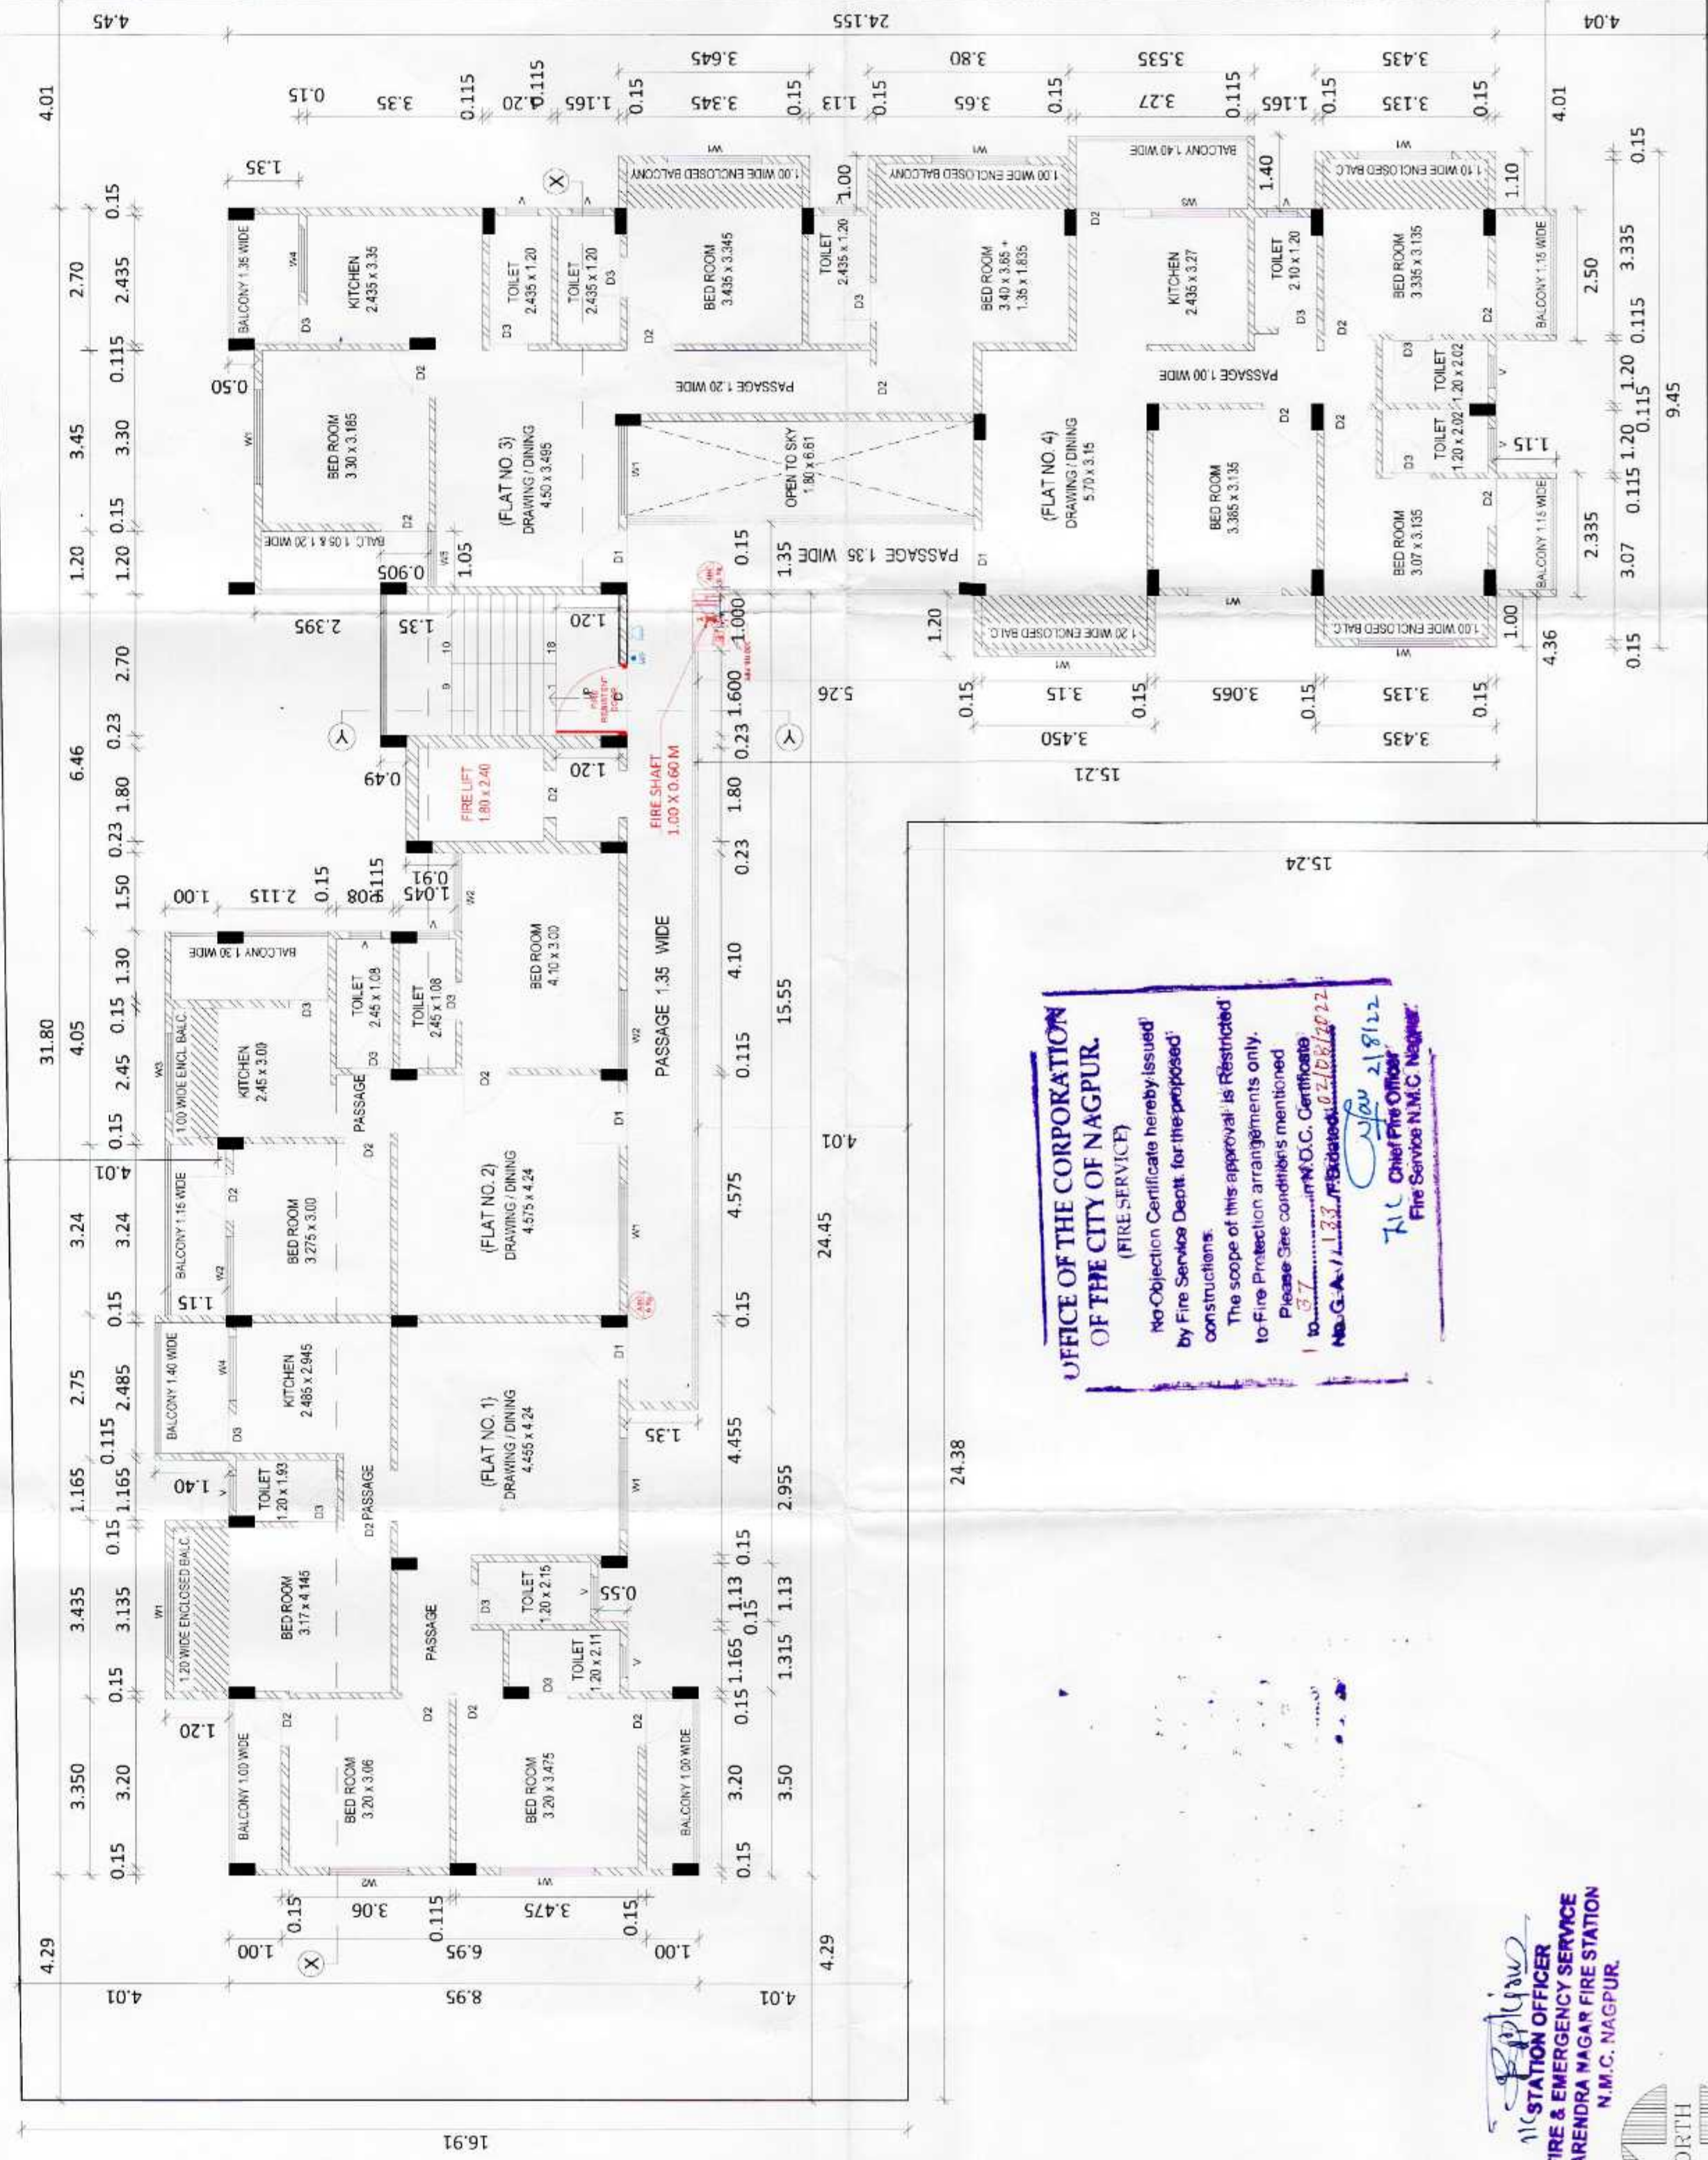

TYPICAL (FIRST TO SIXTH) FLOOR PLAN SCALE 1:100

SHEET NO. 1/2	
PLAN FOR PROPOSED MULTIFAMILY DWELLING UNITS ON PLOT NO. 02, KH. NO. 83/1/1, MOUZA - SOMALWADA, TAH & DIST - NAGPUR BELONGING TO MS. HARIHAR INFRASTRUCTURE DEVELOPMENT CORPORATION LIMITED, NAGPUR.	
F.S.I. B.U.P AREA CALCULATION - (FOR RESIDENTIAL HOUSING TENEMENTS)	
a) NET PLOT AREA FOR F.S.I. CALCULATION (AS PER CLAUSE NO. 3.9 OF UDOPR - 2020) AS PER RELEASE LETTER	928.640 SQM
b) NET P-LINE BUILT UP AREA (AS PER CLAUSE NO. 6.6 OF UDOPR - 2020)	2661.048 SQM
c) FOR RESIDENTIAL USE DIVIDING FACTOR 1.6 TO ARRIVE AT P-LINE AREA / 1.6	2661.048 / 1.6 = 1663.155 SQM
d) FOR NON-RESIDENTIAL USE DIVIDING FACTOR 1.8 TO ARRIVE (BASIC F.S.I. + PREMIUM F.S.I. + TDR = P-LINE AREA / 1.8)	NOT APPLICABLE
e) PERMISSIBLE ANNUAL F.S.I. (AS PER CLAUSE NO. 6.3 TABLE NO. 6-G, NOTE (I) OF UDOPR - 2020) = 5-c-d	(2661.048 - 1663.155) = 997.893 SQM
f) PERMISSIBLE BASIC F.S.I. BUILT UP AREA = (110 x 9)	PROPOSED BASIC F.S.I. @ 1.10 = 1021.504 SQM
g) PREMIUM ADDITIONAL F.S.I. ON CLAUSE NO. 6.3, TABLE NO. 6-G OF CLAUSE NO. 6.3, TABLE NO. 6-G OF TDR (AS PER CLAUSE NO. 6.3, TABLE NO. 6-G OF UDOPR - 2020)	PREMIUM F.S.I. @ 0.50 = 464.320 SQM
h) PERMISSIBLE TDR - (A * PERMISSIBLE TDR) AS PER CLAUSE NO. 6.3, TABLE NO. 6-G OF UDOPR - 2020	0.2 / 185.728 = 0.19 / 177.331
i) PERMISSIBLE TDR FOR ROAD WIDENING WITH COMPLIANCE OF CLAUSE NO. 7.2 & PROFORMA-I	NOT APPLICABLE
j) TOTAL ENTITLEMENT OF F.S.I. (e + f + g + h)	2669.445 SQM
k) MAXIMUM BUILDING POTENTIAL ON PLOT (EXCLUDING ANNUAL F.S.I.)	TOTAL F.S.I. @ 1.60 = 1465.624 SQM
l) PERMISSIBLE ANNUAL F.S.I. (AS PER CLAUSE NO. 6.3, TABLE NO. 6-G, NOTE (I) OF UDOPR - 2020)	F.S.I. @ 0.60 = 997.893 SQM

CERTIFICATE OF AREA

CERTIFIED THAT THE PLOT UNDER REFERENCE WAS SURVEYED BY ME ON 13.05.2022 AND THE DIMENSIONS OF SIZES ETC. OF PLOT STATED ON THIS CERTIFICATE ARE TRUE AND CORRECT AND ARE IN ACCORDANCE WITH THE AREA STATED IN DOCUMENT OF OWNERSHIP / T.P. SCHEME RECORDS / LAND RECORDS DEPARTMENT / CITY SURVEY RECORDS.

LICENCED ENGINEER

PRASHANT UPASANI
LICENCE NUMBER: NMDDA/R/2022/APL/00030
NIT L.S. NO. 512

OWNER'S DECLARATION

I/WE UNDERSIGNED HEREBY CONFIRM THAT I/WE WOULD ABIDE BY PLANS APPROVED BY AUTHORITY / COLLECTOR. I/WE WOULD EXECUTE THE STRUCTURE AS PER APPROVED PLANS. ALSO I/WE WOULD EXECUTE THE CONSTRUCTION AS PER APPROVED PLANS. ALSO I/WE WOULD EXECUTE AS TO ENSURE THE QUALITY AND SAFETY AT THE WORK SITE. SHRI. MANISH ARVIND BODIYANI FOR HARIHAR INFRASTRUCTURE DEVELOPMENT CORPORATION LIMITED

REFERENCE

- LAND USE AS PER SANCTIONS DEVELOPMENT PLAN LOCATION
- ZONE
- PROPOSED BUILDING USE SUBMITTED AS PER PLAN
- PROPOSED CONSTRUCTION SHOWN IN THIS
- EXISTING CONSTRUCTION TO BE RETAINED IN THIS
- EXISTING CONSTRUCTION DEMOLISHED SHOWN IN THIS

NAME OF OWNERS

PRASHANT UPASANI
LICENCE NUMBER
NMDDA/R/2022/APL/00030
NIT L.S. NO. 512

PRASHANT UPASANI
B.E. (Civil), M. Tech. (Structures)
ENGINEER LICENSE NO.: NMDDA/R/2022/APL/00030

ASSOCIATED SPANS

SHRI. MANISH ARVIND BODIYANI
FOR HARIHAR INFRASTRUCTURE DEVELOPMENT CORPORATION LIMITED
PHONE NOS. - 0712-2283313, 9890213029

LEGENDS -

- FIRE DOOR
- ABC FIRE EXTINGUISHER
- CO2 FIRE EXTINGUISHER
- FIRE PUMP
- FIRE ALARM CONTROL PANEL
- FIRE MANUAL CALL POINT
- FIRE HOOTER WITH PA TALK BACK
- FIRE HYDRANT VALVE
- HR-HOSE REEL
- HB-HOSE BOX
- AIR RELEASE VALVE
- BUTTERFLY VALVE
- BALL VALVE
- NRV-NON RETURN VALVE
- BELLOW
- FIRE HYDRANT STAND POST
- FIRE SERVICE INLET
- BUTTERFLY VALVE
- NON RETURN VALVE
- 100 NB PIPE LINE - HYDRANT
- 80 NB PIPE LINE
- 50 NB PIPE LINE

TERRACE TANK DETAILS -
TERRACE TANK FOR FIRE
FIGHTING CAPACITY 25 KL
(3.56 X 4.40 X 1.60 M DEEP)

PUMP DETAILS -
BOOSTER PUMP 900 LPM -
01 NO.

FIRE CONSULTANT -

M/S SS FIRE ENGINEERS
ADD-LAXMI APARTMENT, G-1,
GROUND FLOOR, KUNDE LAYOUT,
RAMESHWARI, NAGPUR - 440010.
NB : 7798121291.
EMAIL : ashish01.chirkute@gmail.com
ashish01.chirkute@gmail.com

LICENCE NO-MFS-LA-RF-291

LICENCE NO-MFS-LA-RD-286

FIRE CONSULTANT SEAL & SIGN-

Authorised Government LIC
Agency of Maharashtra State
S. S. Fire Engineers
Lic. No. MFS-Eng-2018RD-286
Authorised Signatory

AUTHORISED SIGNATORY
DESIGN BY -
DRAWN BY -
CHECKED BY -
DATE -
SCALE -
SHEET -
FF-REV-1
01 OF 02
APPROVED BY -
ASHISH C.