
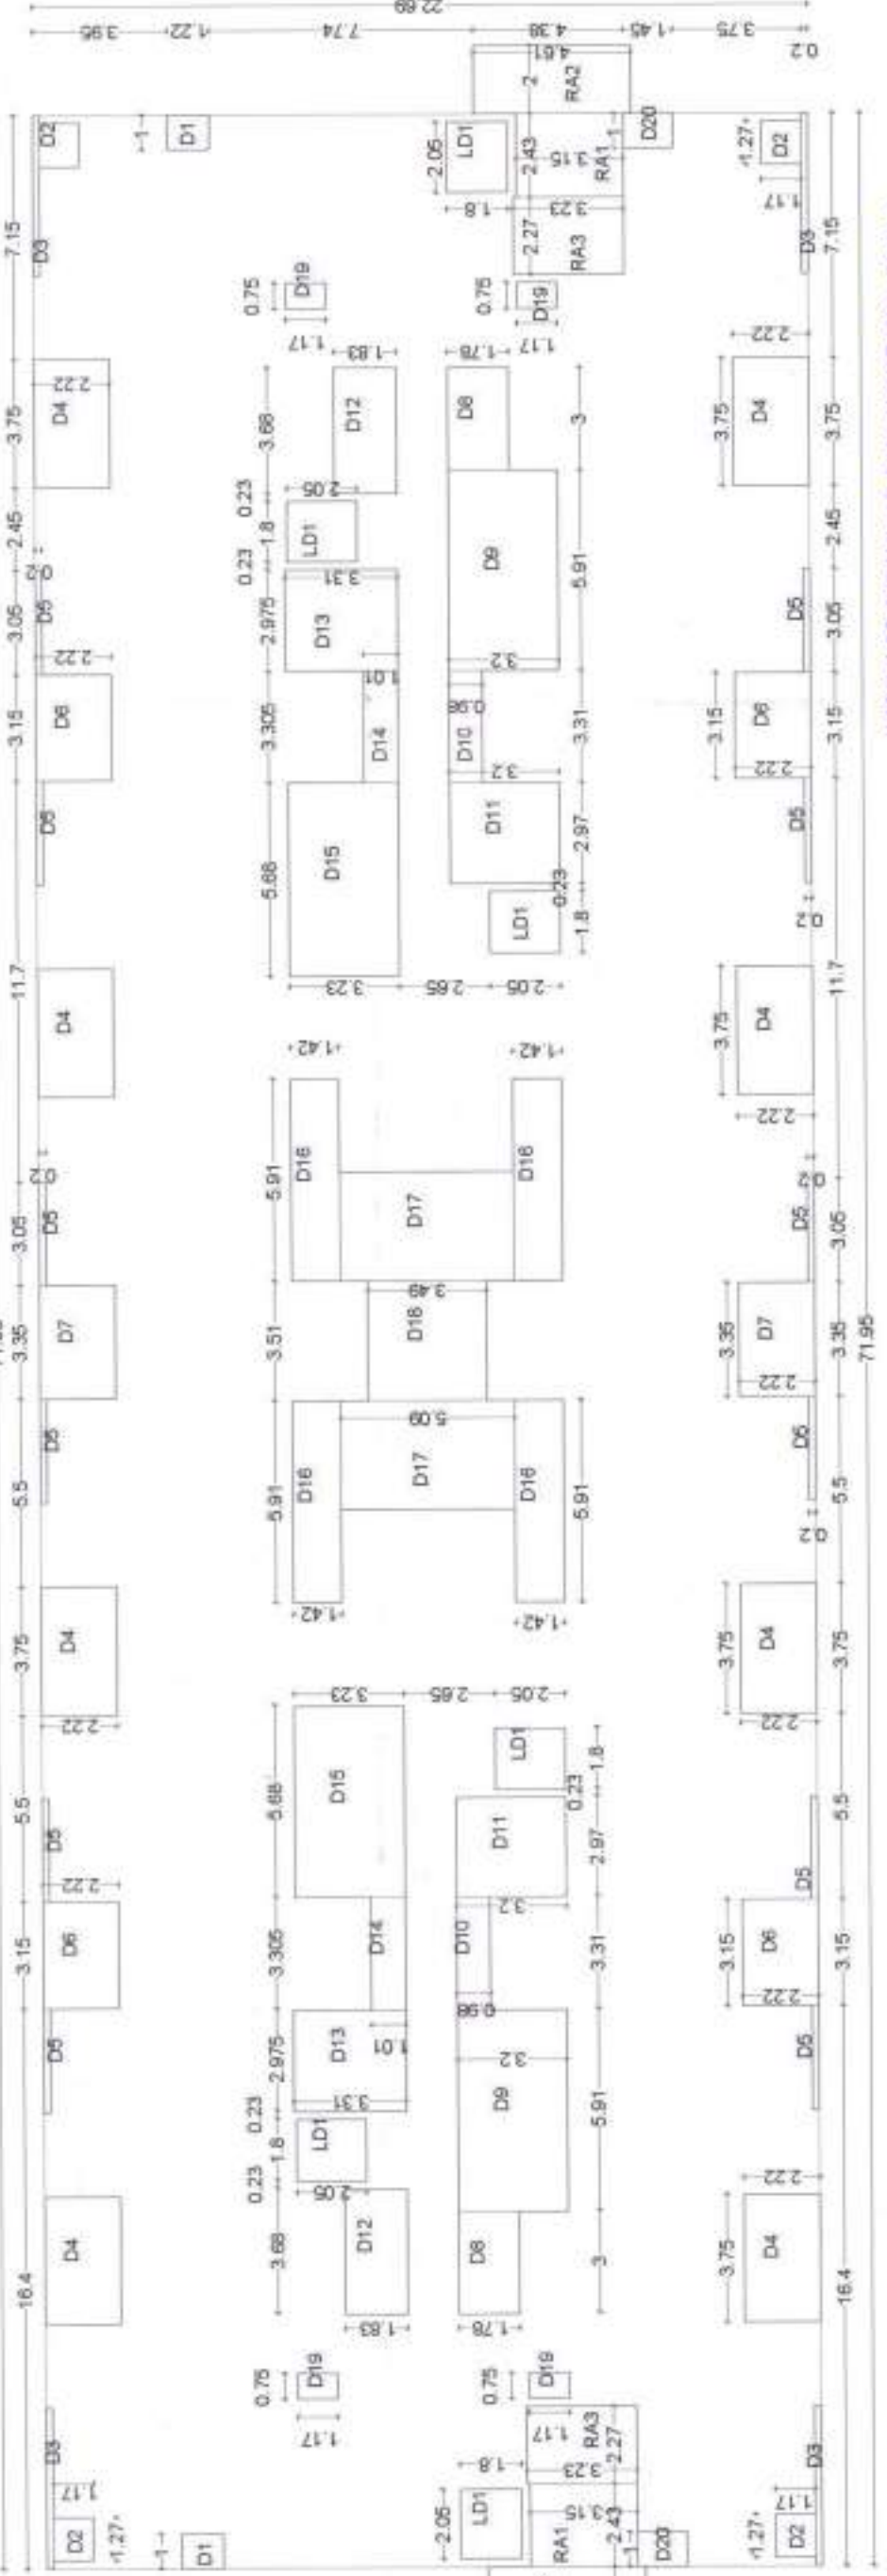


SUBMISSION DRAWING	SH NO.
PROPOSED RESIDENTIAL BUILDING AT PLOT NO. 01 SITUATED AT KINHO - 1892, P.H. NO. 38, MOUZA - PIPLA, TAH - NAGPUR (GRAMINI), BELONGING TO - MR. KAMLESH SAMPAT RAO BEDE	02
APPROVAL STAMP	
FIRE DOOR	
ABC FIRE EXTINGUISHER	
CO2 FIRE EXTINGUISHER	
FIRE PUMP	
FIRE SPRINKLE - PENDENT TYPE 48°C	
FIRE ALARM CONTROL PANEL	
FIRE MANUAL CALL POINT	
FIRE HYDRANT VALVE	
NR-HOSE REEL	
NR-HOSE BOX	
NR-HOSE DETECTOR & RECEIVER	
NR-SMoke DETECTOR	
NR-SMoke DETECTOR	
NR-RELEASE VALVE	
NR-BALL VALVE	
NR-NON RETURN VALVE	
NR-Y STRAINER	
NR-FIRE HYDRANT STAND POST	
NR-FIRE SERVICE INLET	
NR-BUTTERFLY VALVE	
NR-NON RETURN VALVE	
NR-100 NB PIPE LINE - HYDRANT	
NR-80 NB PIPE LINE - HYDRANT	
NR-50 NB PIPE LINE	
NR-40 NB PIPE LINE	
NR-25 NB PIPE LINE	

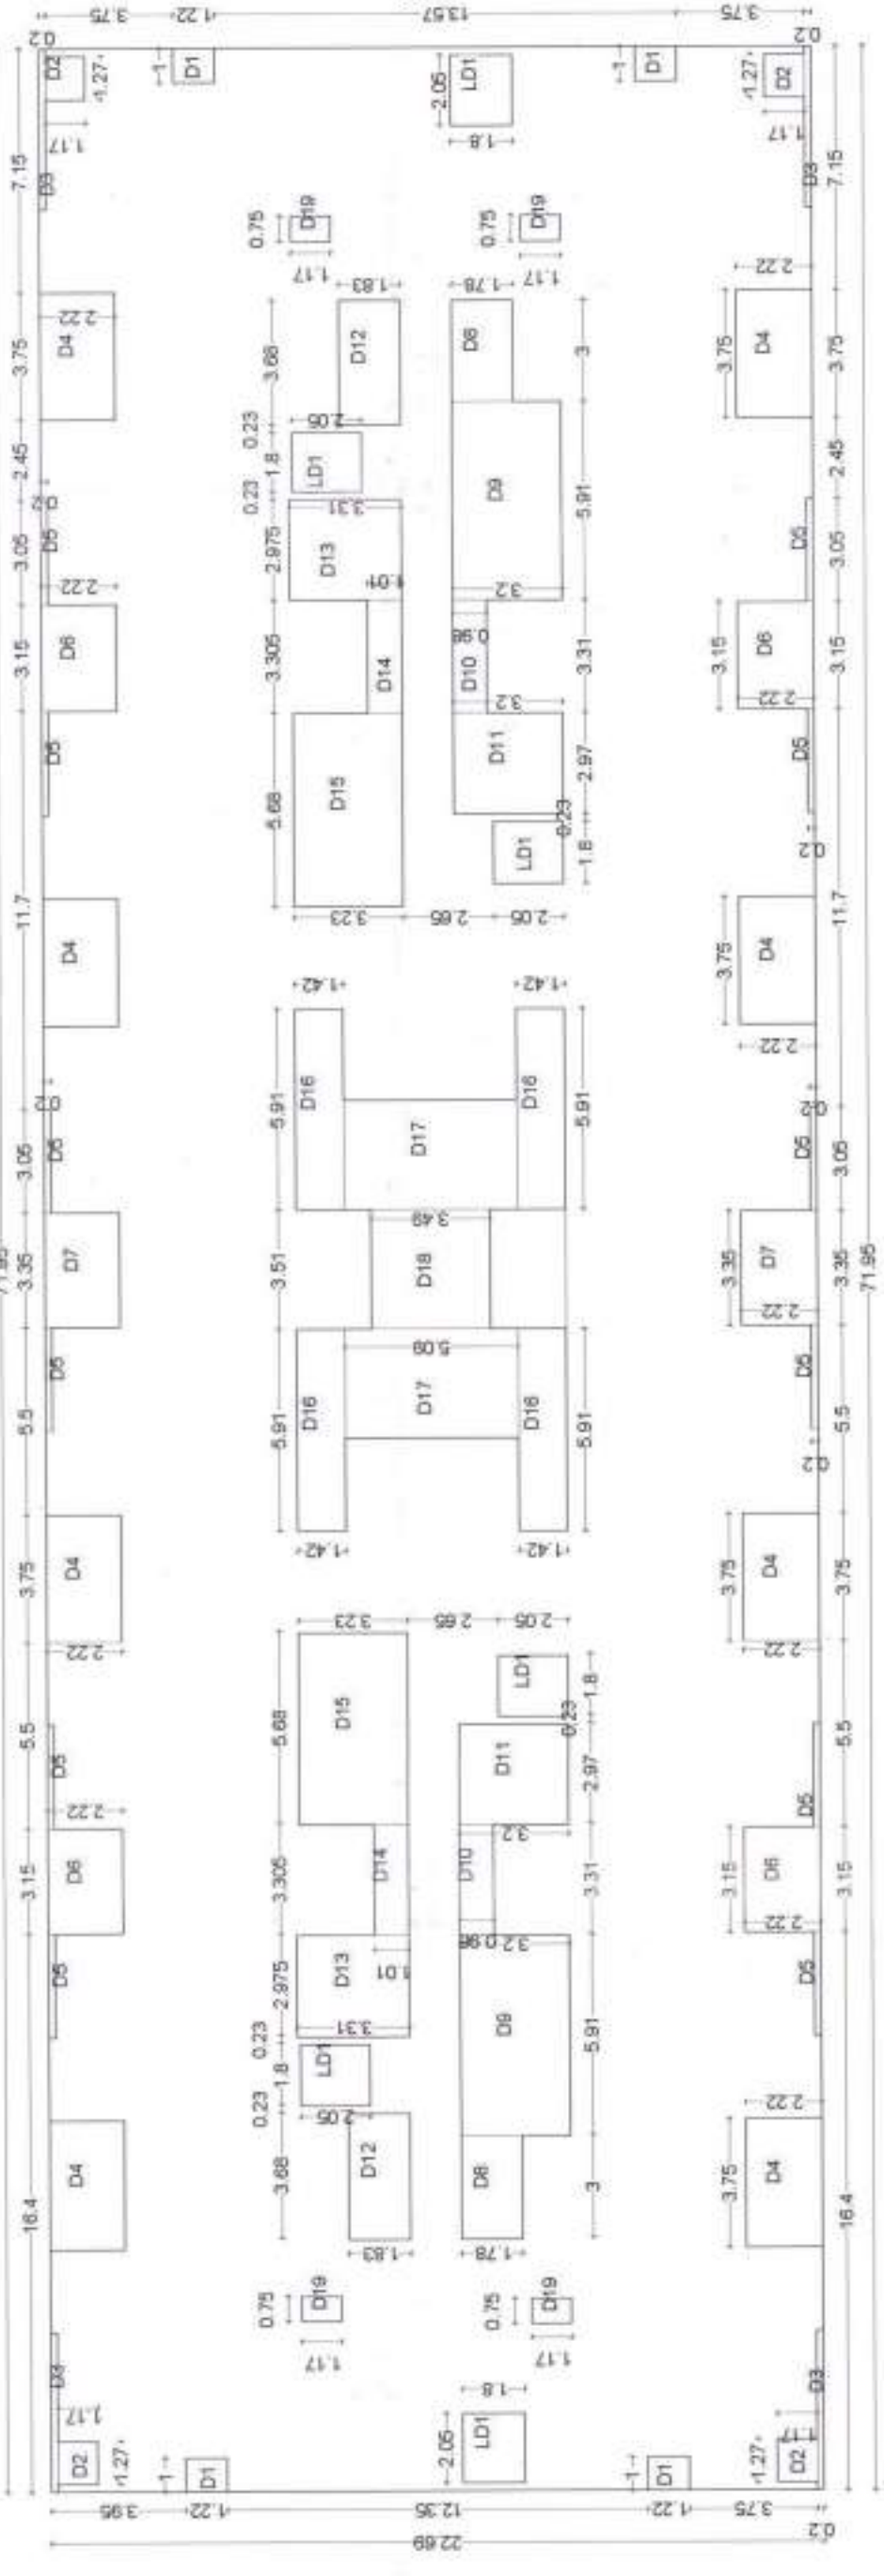


BUILT-UP AREA CALCULATION EIGHTH FLOOR VINAYAN RESIDENTIAL


Office of the Municipal Engineer, Nagpur
Date: 21/09/2023

Subject to Condition of N.O.C. of Airport
Authority Dt. 21/09/2023

Subject to the condition of the Airport Authority, Nagpur, for the purpose of the Airport, the building shall be used as a residential building and shall not be used for any other purpose.

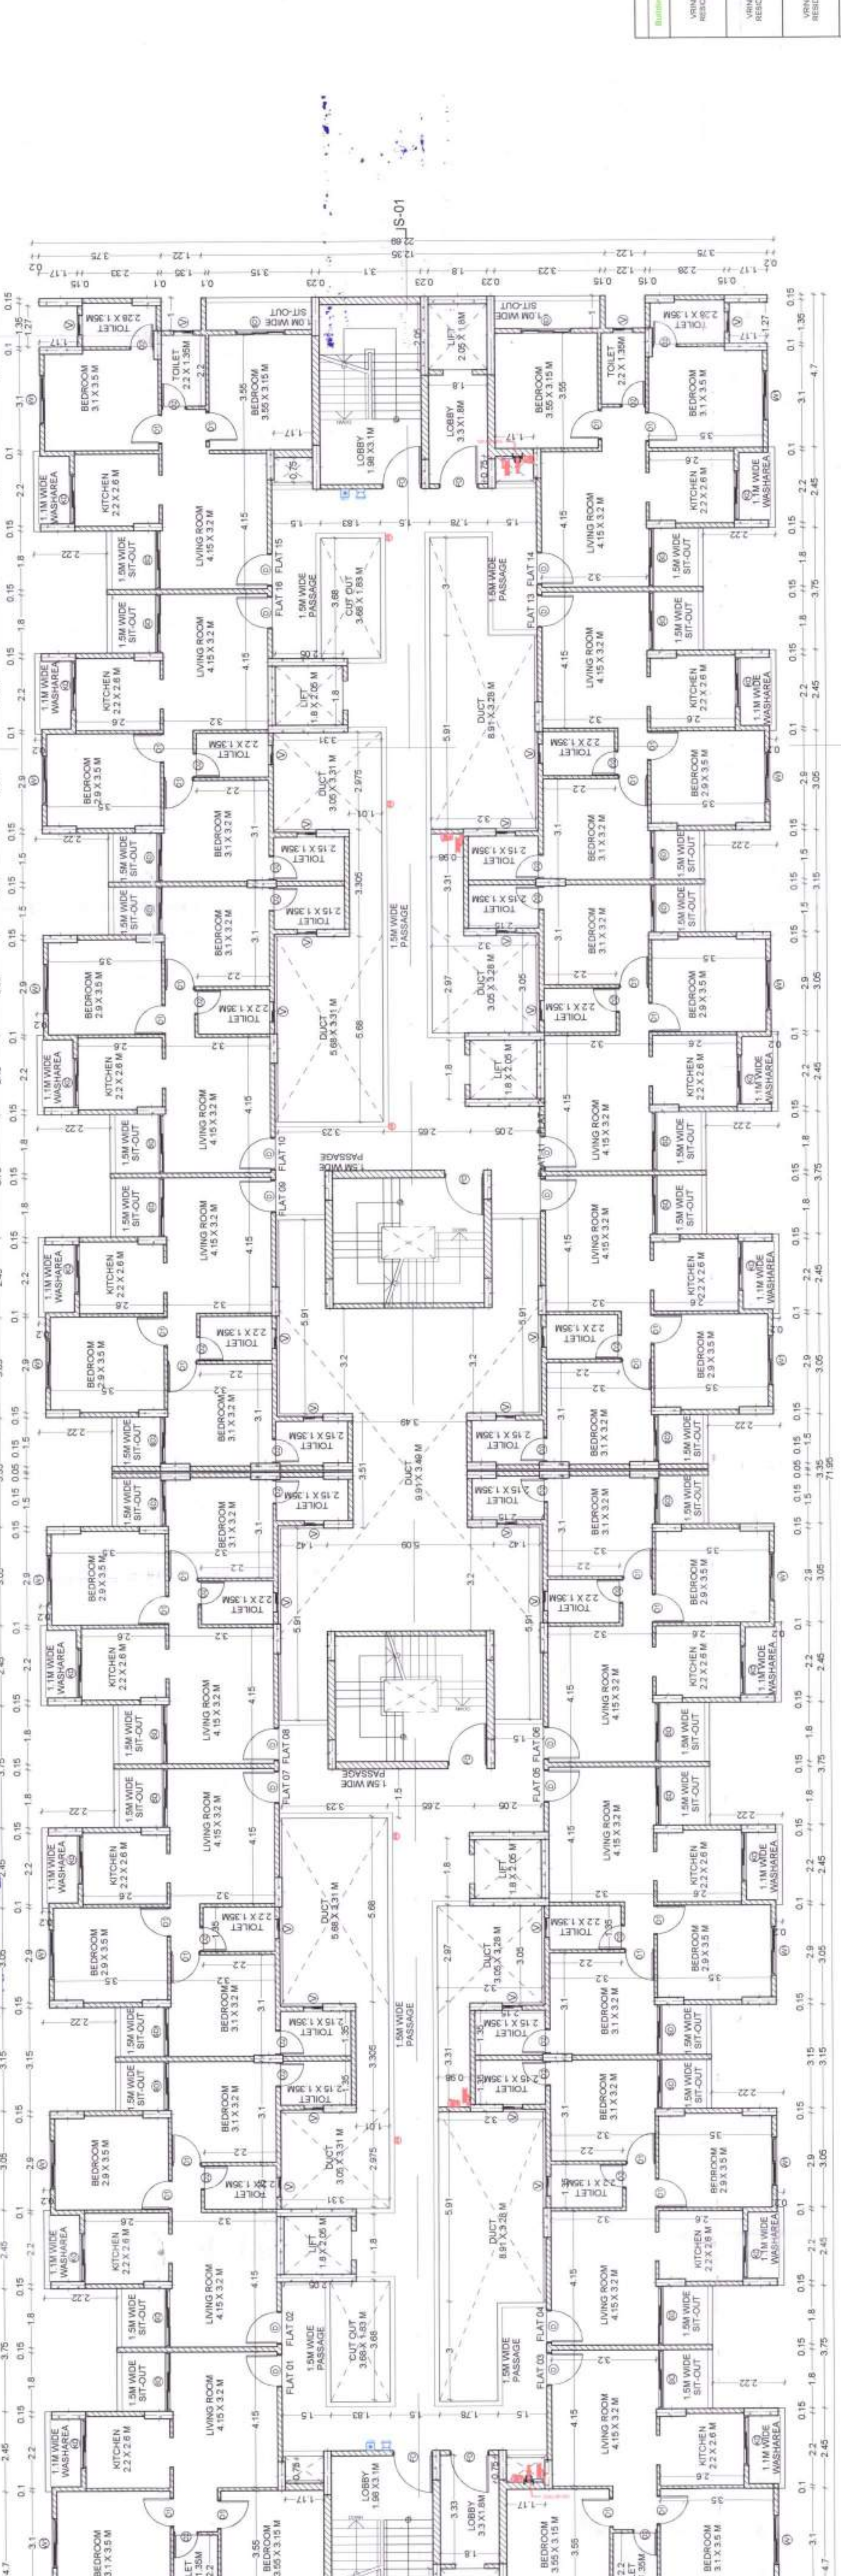

TYPICAL 1ST TO 9TH TO 11TH FLOOR PLAN
SCALE: (1:100)

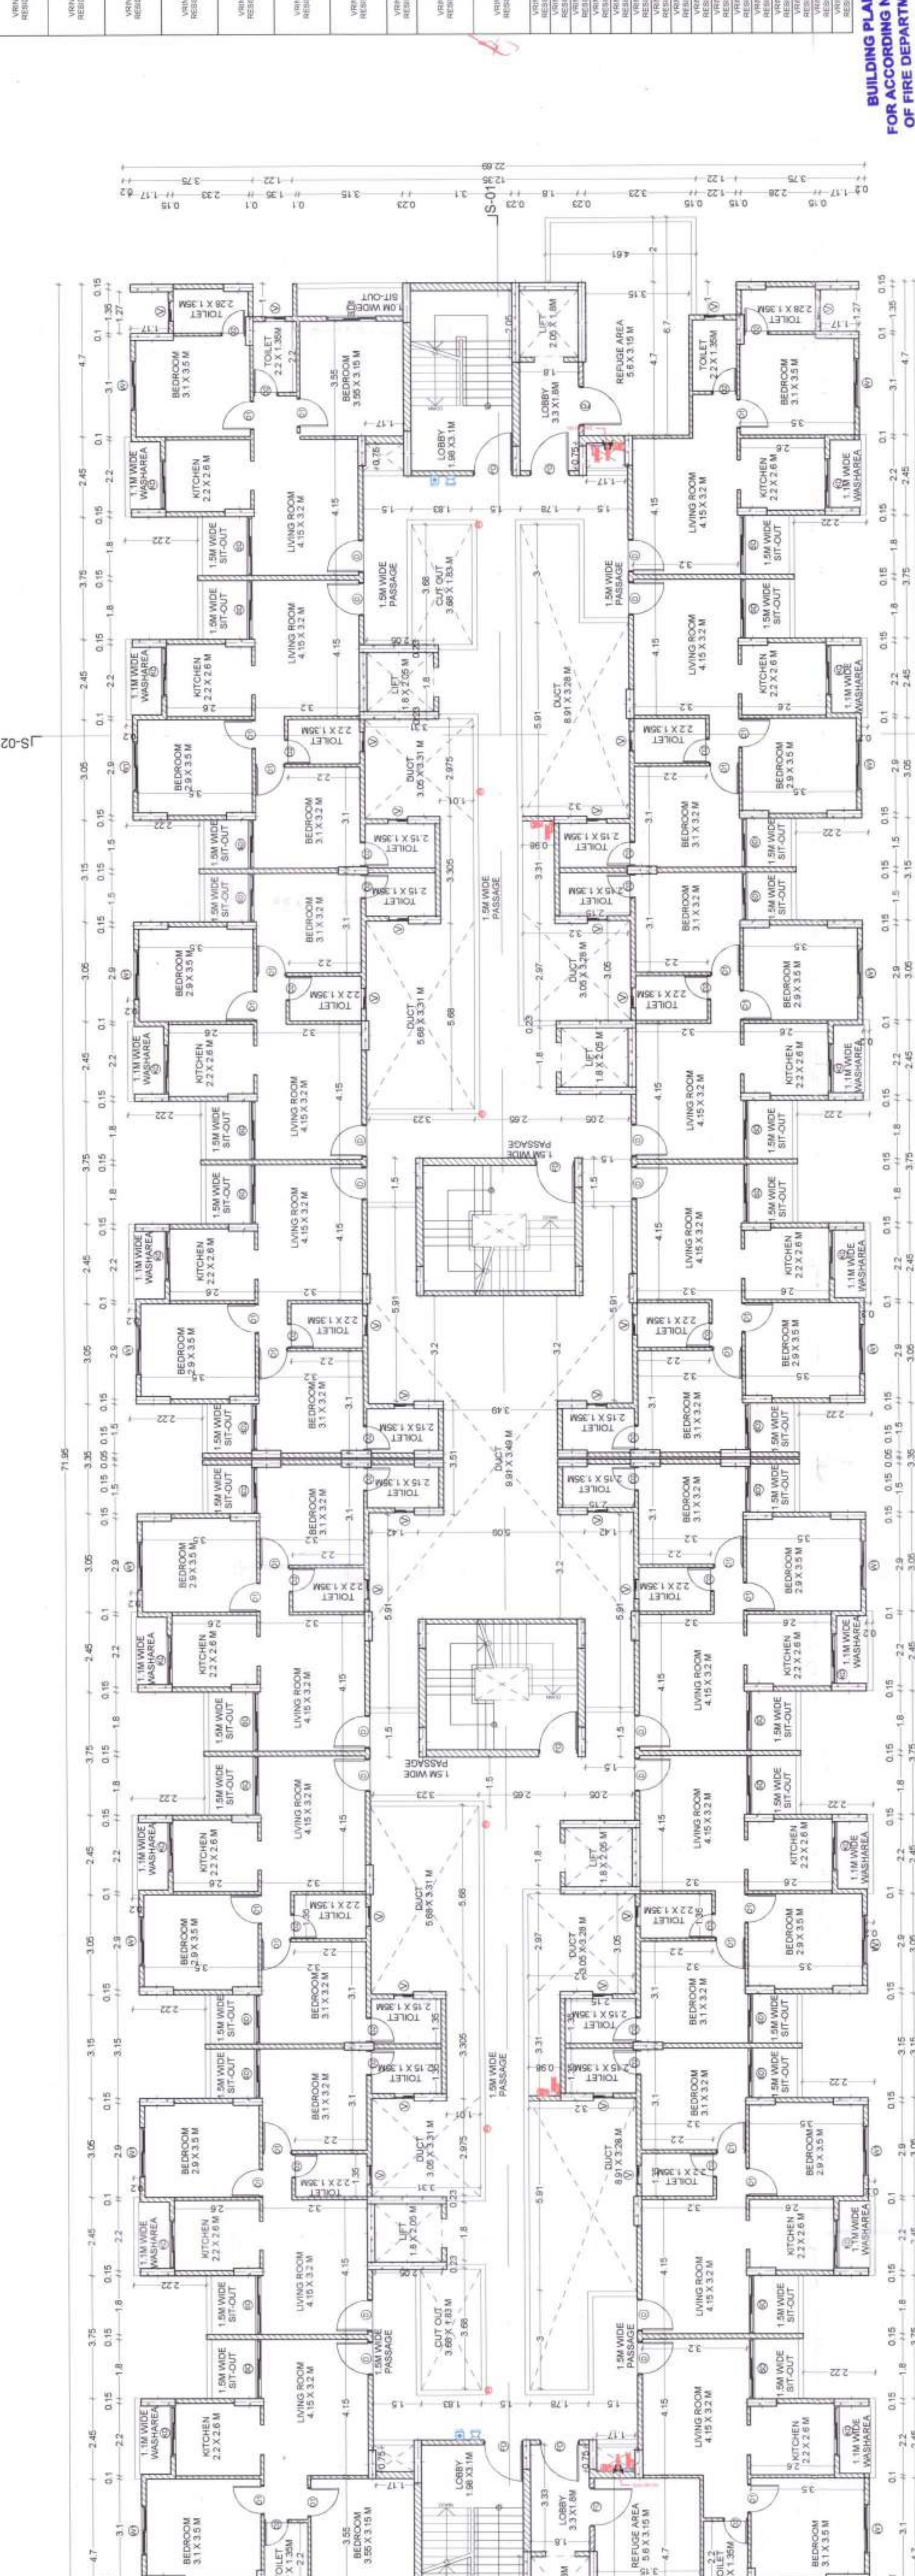

8TH FLOOR PLAN (REFUGE FLOOR)
SCALE: (1:100)

Sl. No.	Particulars	Area (sq. m.)
1	Living Room	10.00
2	Kitchen	5.00
3	Bedroom	10.00
4	Toilet	2.00
5	Bathroom	2.00
6	Veranda	1.00
7	Staircase	1.00
8	Corridor	1.00
9	Room	1.00
10	Room	1.00
11	Room	1.00
100	Room	1.00

FIRE CONSULTANT

Site Address: Plot No. 01, Mouza - Pipla, Tah - Nagpur, Dist - Nagpur, M.P.

Project Name: Proposed Residential Building at Plot No. 01, Mouza - Pipla, Tah - Nagpur, Dist - Nagpur, M.P.

Scale: 1:100

Check By: [Signature]

Submission Drawing

License No. MYS/LA/R-478/RD-460/RP-28

1. Fire Fighting Engineer (FF-1)

2. Fire Fighting Engineer (FF-2)

3. Fire Fighting Engineer (FF-3)

100. Fire Fighting Engineer (FF-100)

FIRE AND EMERGENCY SERVICE

APPROVED

DATE: 21/09/2023

Signature: [Signature]

Stamp: [Stamp]

For the purpose of the fire and emergency service, the building shall be used as a residential building and shall not be used for any other purpose.

BUILDING PLAN FOR ACCORDING N.O.C. OF FIRE DEPARTMENT

Office of the Municipal Engineer, Nagpur

Date: 21/09/2023

Subject to the condition of the Airport Authority, Nagpur, for the purpose of the Airport, the building shall be used as a residential building and shall not be used for any other purpose.