


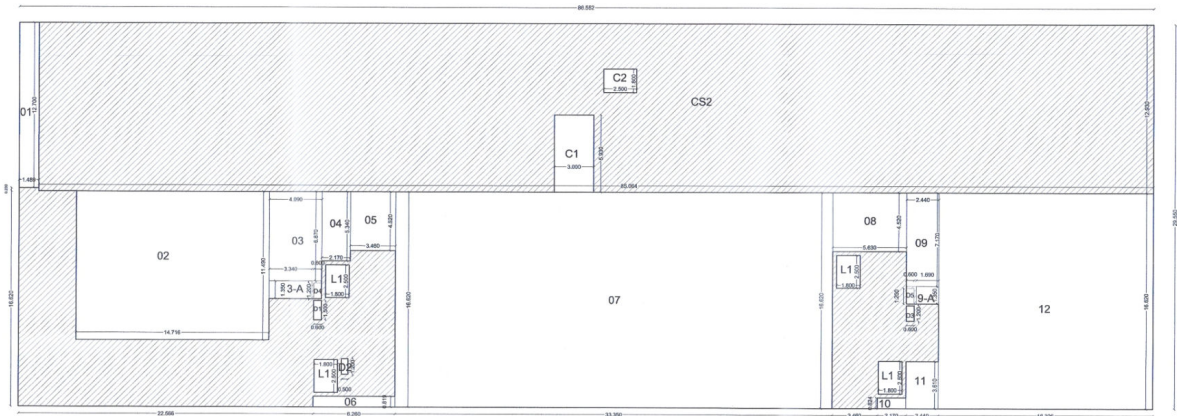


BLOCK PLAN FIRST FLOOR
(SCALE 1:200)

WING COMMERCIAL

Necessary arrangement for Rain water harvesting shall be done

FIRST FLOOR F-LINE AREA RESIDENTIAL			
BLOCK	LENGTH X WIDTH X NOS	AREA	UNIT
1 FF	86.552 X 29.550 X 1	2557.612	SQ.M.
TOTAL		2557.612	SQ.M.
DEDUCTIONS			
C32	85.044 X 12.930 X 1	1099.878	SQ.M.
1	1.489 X 12.930 X 1	19.170	SQ.M.
2	1.471 X 11.490 X 1	16.897	SQ.M.
3	4.090 X 6.870 X 1	28.098	SQ.M.
3A	3.340 X 1.350 X 1	4.509	SQ.M.
4	2.170 X 5.340 X 1	11.588	SQ.M.
5	3.460 X 4.530 X 1	15.639	SQ.M.
6	4.200 X 0.819 X 1	3.422	SQ.M.
7	33.300 X 1.640 X 1	54.577	SQ.M.
8	5.630 X 4.530 X 1	25.448	SQ.M.
9	2.440 X 7.170 X 1	17.495	SQ.M.
9A	1.480 X 1.350 X 1	2.000	SQ.M.
10	2.170 X 0.824 X 1	1.788	SQ.M.
11	7.440 X 3.410 X 1	25.580	SQ.M.
12	16.306 X 1.640 X 1	26.736	SQ.M.
L1	1.800 X 2.500 X 4	18.000	SQ.M.
D1	0.600 X 1.500 X 1	0.900	SQ.M.
D2	0.500 X 1.500 X 1	0.750	SQ.M.
D3	0.600 X 1.500 X 1	0.900	SQ.M.
D4	0.600 X 1.500 X 1	0.900	SQ.M.
D5	0.600 X 1.500 X 1	0.900	SQ.M.
TOTAL DEDUCTIONS		2055.999	SQ.M.
FIRST FLOOR RESIDENTIAL		501.613	SQ.M.
FIRST FLOOR F-LINE AREA COMMERCIAL			
BLOCK	LENGTH X WIDTH X NOS	AREA	UNIT
COMMERCIAL AREA (C32)		1099.878	SQ.M.
C1	3.000 X 5.930 X 1	17.790	SQ.M.
C2	2.500 X 1.800 X 1	4.500	SQ.M.
TOTAL COMMERCIAL F-LINE AREA		1077.588	SQ.M.

OFFICE OF THE NAGPUR IMPROVEMENT TRUST
Building Permit No. 1524/154/17/NO-2023060716/791
Date: 24.08.2024
SANCTIONED
As Corrected Only
Building Engineer (East)
Nagpur Improvement Trust, Nagpur.

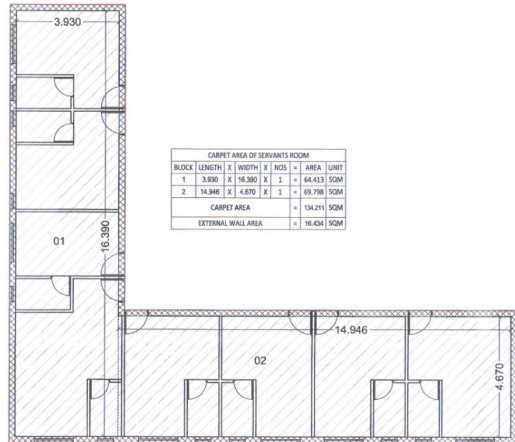

Tentatively approved for
N.O.C. from Chief Fire
Officer, N.M.C. Nagpur.

Building Engineer (East)
Nagpur Improvement
Trust, Nagpur.

LEGENDS

SR.NO.	PARTICULAR	SYMBOL
01	PIPE	—
02	4WAY FIRE BRIGADE INLET	—
03	HYDRANT VALVE	—
04	HOSE BOX	—
05	HOSE REEL	—
06	BUTTERFLY VALVE	—
07	MANUAL CALL POINT	—
08	HOOTER	—
09	PENDENT SPRINKLER	—
10	WALL MOUNTED SPRINKLER	—
11	DETECTOR	—
12	ABC EXTINGUISHER	—
13	CO2 EXTINGUISHER	—
14	PA SPEAKER	—
15	FIRE TENDER	—
16	FIRE JET FAN	—

ALL DIMENSIONS ARE IN METERS UNLESS OTHERWISE NOTED.

PROJECT	FIRE PROTECTION & ALARM SYSTEM
CLIENT	SANDEEP DWELLERS PVT. LTD.
CONTRACTOR	OYSTER INFRA-CON PVT. LTD.
DRAWN	PD
CHECKED	GR
APPROVED RT	MOUZA CHIKHALI, NAGPUR, MAHARASHTRA.
DATE	10/11/2023
SHEET NO	01
DRAWING NO	OIP/NGP/FF/00542
REV	00
LICENSE NO	MFS / LA / R - 464 / RD - 434 / RP - 96
FIRE FIGHTING SYSTEM CONSULTANT	STAMP & SIGNATURE

OYSTER
INFRA-CON PVT. LTD.

PLOT BOUNDARY SHOWN THUS
PROPOSED CONSTRUCTION SHOWN AS
EXISTING CONSTRUCTION SHOWN AS

ALL DIMENSIONS ARE IN METERS

DATE	SCALE	DRAWN BY	CHECKED BY
------	-------	----------	------------

06/06/2023	1:100,1:200	ALOK	RAHUL
------------	-------------	------	-------

OWNER ARCHITECT

For Karris Food and Snacks Pvt. Ltd.

Authorised Signatory



RAHUL AGARWALA
C.O.A. REGD NO. CA2008/41949
N.I.T.S.NO.:2310
N.M.C. - R : 529

WING - A

STATION OFFICER (HQ)
FIRE & EMERGENCY SERVICE
N.M.C., NAGPUR

FIRST FLOOR PLAN
(SCALE 1:100)

WING - B