




WEST SIDE ELEVATION
(SCALE :- 1:100)

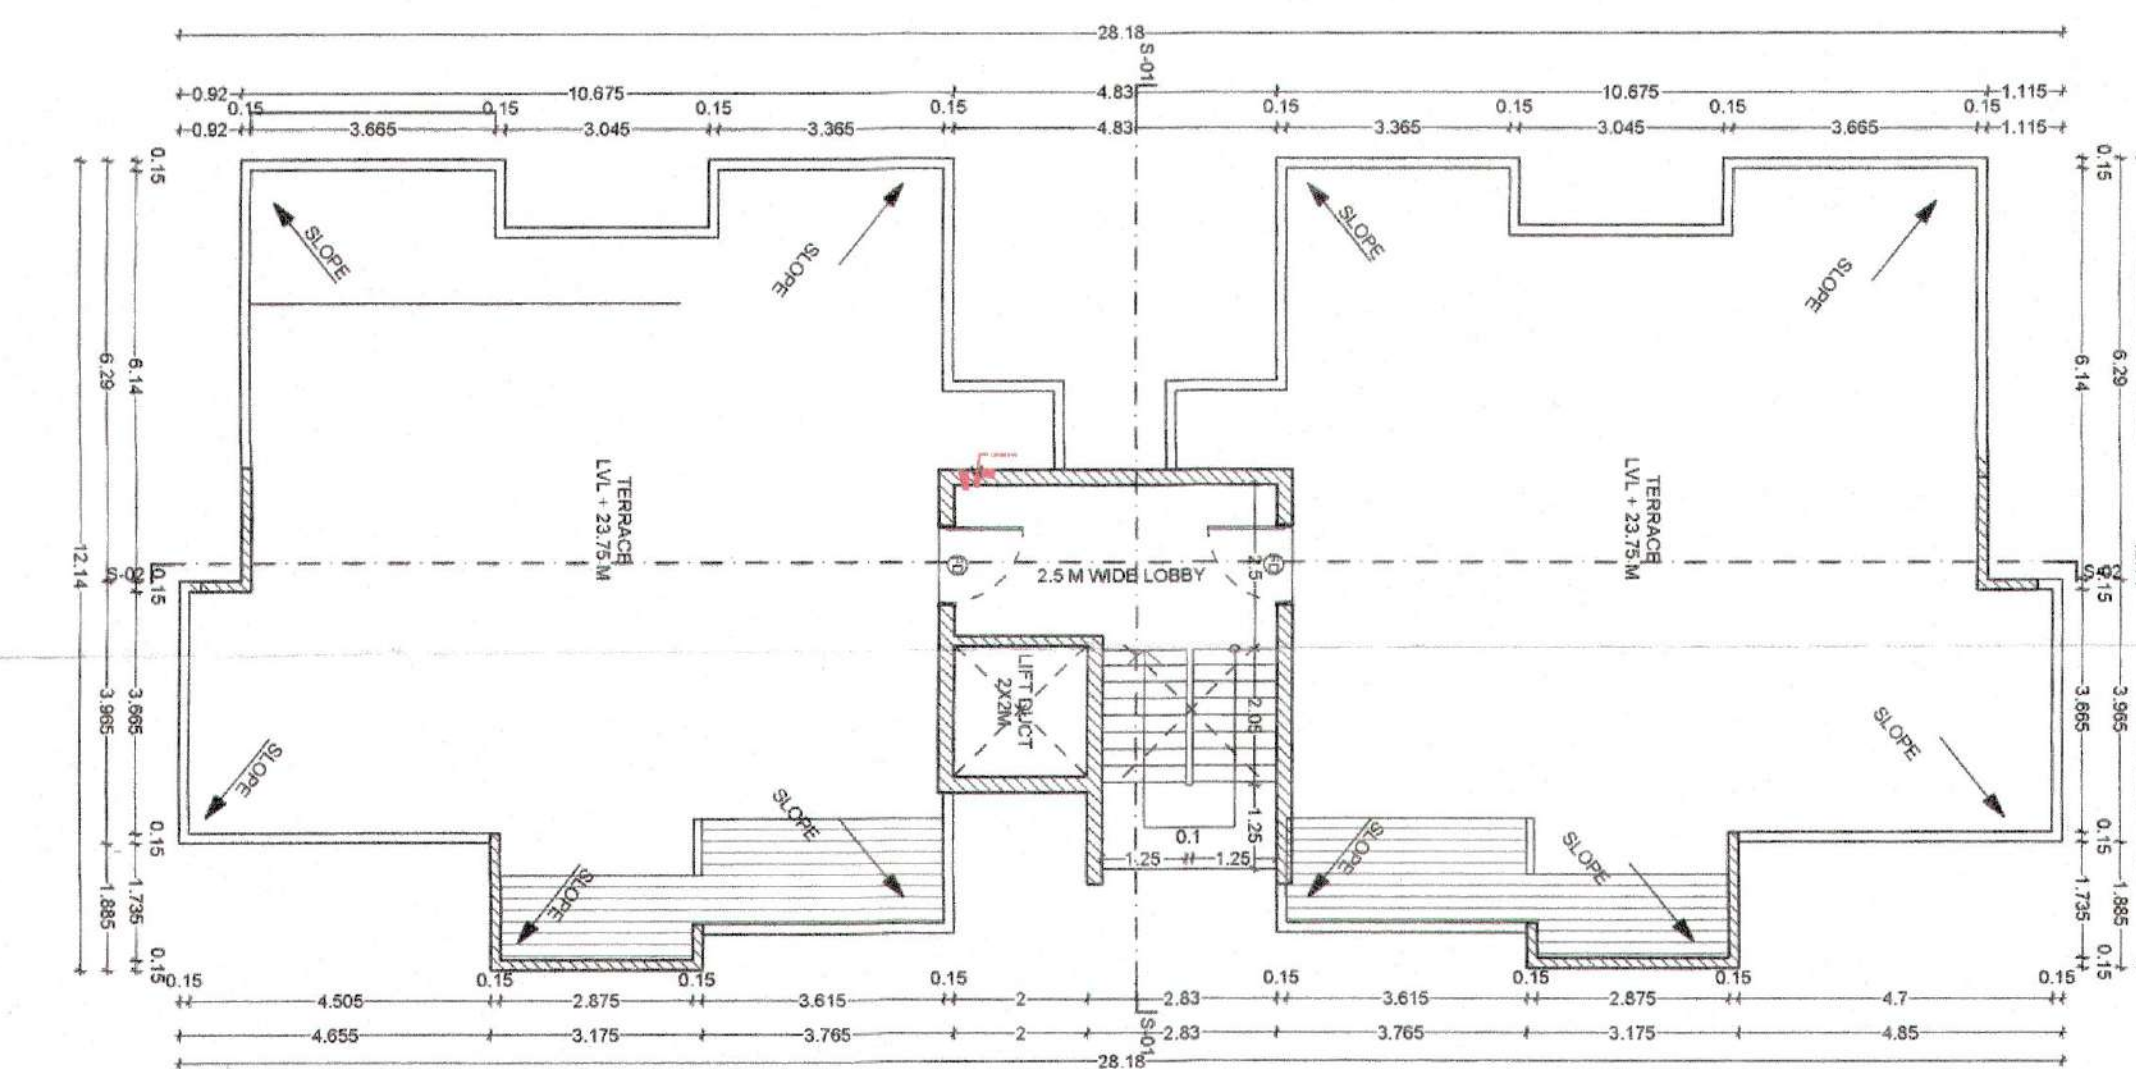


TERRACE FLOOR PLAN
(SCALE :- 1:100)



Subject to the condition as per
Regularisation Letter dt. 14/12/23

SECTION S-02
(SCALE :- 1:100)

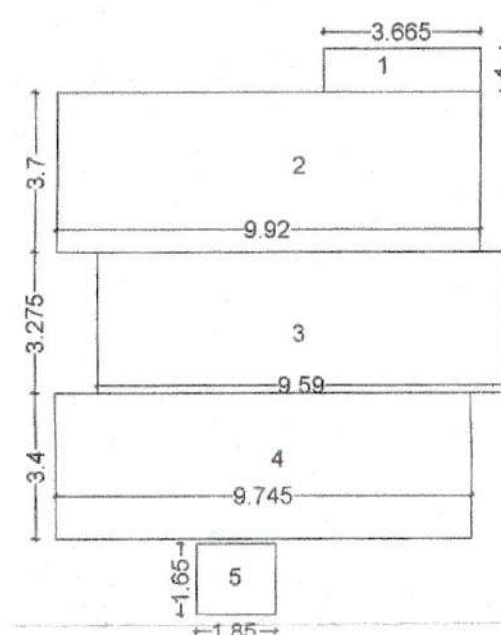


AREA BLOCK DIAGRAM OF CARPET AREA
FOR TYPICAL FLAT
(SCALE :- 1:200)

**FIRE AND EMERGENCY SERVICE
APPROVED**
VIDE LETTER NO. C/O/FES/ DATE / /
(The Scope of this approval is restricted to
fire protection arrangements only, this approval
should not be treated / presumed as approval
for Civil/Architectural drawings)
Chief Fire Officer
N.M.R.D.A./N.I.T., Nagpur

For Safety Point of view only
signed in token of Approved subject to
no requirement of N.C.C. for requirement of N.C.C.

CARPET AREA CALCULATION FOR FLAT NO. 01 & 02					
S.No.	Type	Number	Dimension		Answer in SQ.M.
			Length	Breadth	
ADDITION					
1	RECTANGLE	1	3.665	1	3.665
2	RECTANGLE	1	9.92	3.7	36.704
3	RECTANGLE	1	9.59	3.275	31.407
4	RECTANGLE	1	9.745	3.4	33.133
5	RECTANGLE	1	1.85	1.65	3.053
TOTAL ADDITION AREA=					107.961

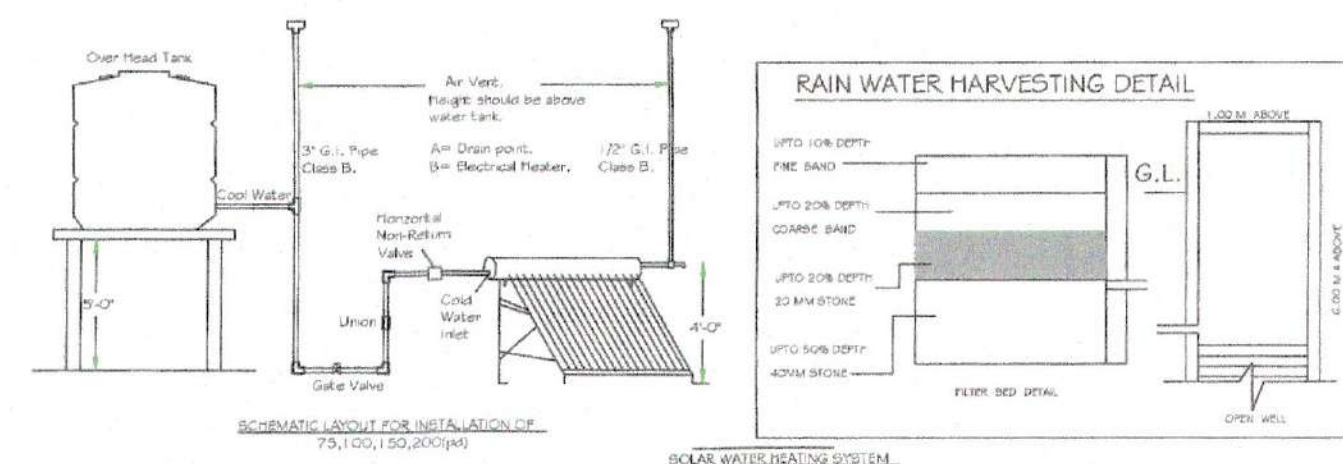

SUBMISSION DRAWING SH.NO.
02/02
PROPOSED RESIDENTIAL BUILDING ON PLOT NO.20,
MOLUZA - KACHIMET KH.NO. 41842 CITY SURVEY NO.64,
SHEET NO.102/213, TAY & DIST. NAGPUR,
BELONGING TO - MS ANGEL DWELLERS INFRA TECH
PVT.LTD
THROUGH PARTNER - SHREE RAHUL N. AGRAWAL

APPROVAL STAMP:

Door Schedule			
Element ID	W x H Size	Stilt Height	Lintel height
D	1x2.3	0.05	2.35
D1	0.9x2.3	0.05	2.35
D2	0.75x2.3	0.05	2.35
FD	1.2x2.3	0.05	2.35
KW	1.5x1.2	1.15	2.35
V	0.75x1.1	1.25	2.35

Window Schedule			
Element ID	W x H Size	Stilt Height	Lintel height
W1	2.15x1.7	0.65	2.35
W2	1x1.7	0.65	2.35

BOUNDARY OF PLOT SHOWN IN
EXISTING WORK SHOWN IN
PROPOSED WORK SHOWN IN
Certified that the plot under reference was surveyed by me on
and the dimensions of sides etc. of plot stated on plan
are as measured on site and the area so worked out tallies with the
area stated in document of Ownership T.P. Scheme Records/ Land
Records Department/City Survey records.

Signature
(Name of Architect/ Licensed Engineer/ Supervisor)

Owner's Declaration
I/We undersigned hereby confirm that I/We would abide by plans
approved by Authority / Collector.
I/We would execute the structure as per approved plans. Also I/We
would execute the work under supervision
of proper technical person so as to ensure the quality and safety at
the work site.

Owner (s) name and signature

Architect name : Ar. Parag Kothwal
Signature:

License no.

Registration No. of Architect

Job No. Drawing Scale Drawn by Checked by

DRAWING TITLE

TERRACE PLAN, ELEVATION
& SECTION -02

NORTH

N

DRN BY: AJINKYA

CHECKED BY:

DATE: 26-05-2023

SCALE: 1:100, 1:200

OWNER:

SIGNATURE:

MS ANGEL DWELLERS INFRA TECH
PVT.LTD
FLAT NO.20, MOLUZA, KACHIMET KH.NO. 41842 CITY SURVEY NO.64,
SHEET NO.102/213, TAY & DIST. NAGPUR,
BELONGING TO - MS ANGEL DWELLERS INFRA TECH
PVT.LTD
THROUGH PARTNER - SHREE RAHUL N. AGRAWAL

ARCHITECT:

SIGNATURE:

Ekveera Architects M/s Ekveera Architects
PVT.LTD
218, 3RD FLOOR, OFF. SANGHVI
GROUND, ASHAPUR NAGAR,
NAGPUR-460010
(02012) - 2248867
EMAIL: mail@ekveera.org

Authorised Signatory

DATE - 12/08/2023

CHECKED BY -

SCALE - 1:100

APPROVED BY -

LEGENDS -

- FIRE DOOR
- ABC FIRE EXTINGUISHER
- CO2 FIRE EXTINGUISHER
- FIRE PUMP
- FIRE SPRINKLE - PENDENT TYPE - 68°C
- FIRE ALARM CONTROL PANEL
- FIRE MANUAL CALL POINT
- FIRE HOOTER WITH PA TALK BACK
- FIRE HYDRANT VALVE
- HR-HOSE REEL
- HB-HOSE BOX
- BD-BEAM DETECTOR & RECEIVER
- HD-HEAT DETECTOR
- RI-RESPONSE INDICATOR
- SD-SMOKE DETECTOR
- AIR RELEASE VALVE
- BUTTERFLY VALVE
- BALL VALVE
- NRV-NON RETURN VALVE
- FIRE HYDRANT STAND POST
- FIRE SERVICE INLET
- BUTTERFLY VALVE
- NON RETURN VALVE
- 100 NB PIPE LINE - HYDRANT
- 100 NB PIPE LINE - SPRINKLER
- 80 NB PIPE LINE
- 65 NB PIPE LINE
- 50 NB PIPE LINE
- 40 NB PIPE LINE
- 32 NB PIPE LINE
- 25 NB PIPE LINE

OFFICE OF THE NAGPUR IMPROVEMENT TRUST
Building Permit No. 13/11/2023
Date 13/11/2023
SANCTIONED
Building Engineer (West)
Nagpur Improvement Trust

FIRE CONSULTANT -

FIRE FIGHTING CONSULTANT
Govt. Approved Fire Licence Agency
SAFE BELL INDIA PVT. LTD.
Add: 105, Gardenia, Shankar, Warsha Road, Nagpur
Contact No.: 9325517560 Email: safebell@gmail.com

License No. MFS / LA / RF-478 / RD-460 / RP-98
valid for a period from 23.09.2022 to 22.09.2023

1. Fire Fighting and Sprinkler System: Class D
2. Detection and Fire Suppression System: Class D
3. Passive System: Class D

FIRE CONSULTANT SEAL & SIGN-

AUTHORISED SIGNATORY

DRAWN BY -

DESIGNED BY -

DATE - 12/08/2023

CHECKED BY -

SCALE - 1:100

APPROVED BY -

FF-REV-02
02 OF 02